
PDA2024-04 Appendix C Site Plan Drawings

10045 HIGHWAY 26 COMMERCIAL DEVELOPMENT


TOWN OF COLLINGWOOD



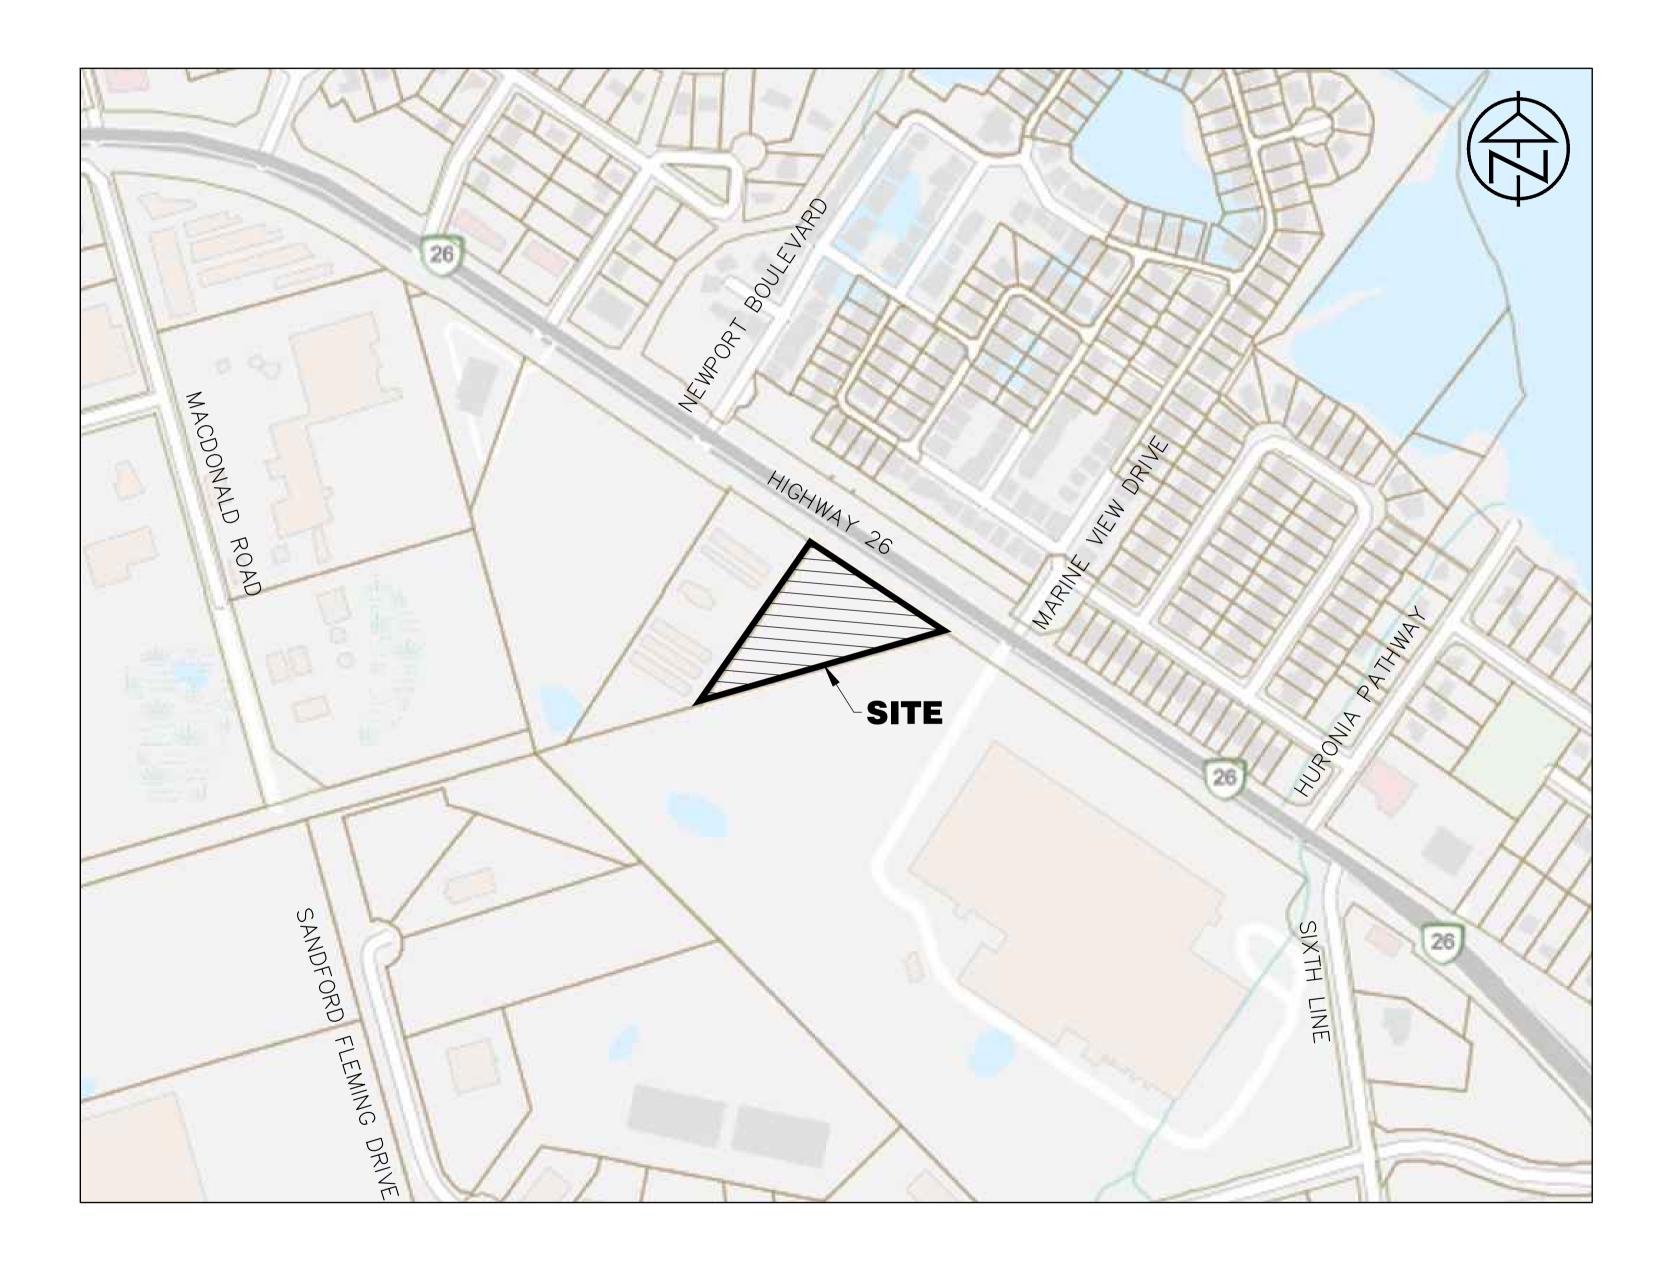



SECOND SUBMISSION SEPTEMBER 6, 2024

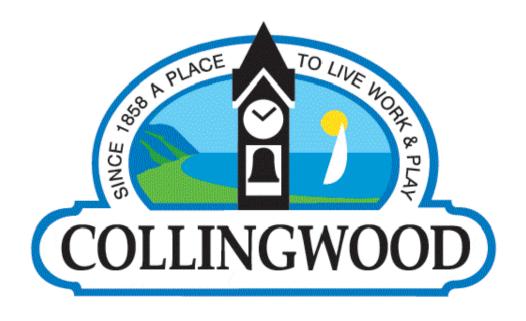

INDEX

DRAWING DESCRIPTION TITLE PAGE INDEX SHEET SP1 SITE PLAN TRK1 TRUCK TURNING TEMPLATE

EROSION AND SEDIMENT CONTROL PLAN ESC1

SS1 SITE SERVICING PLAN SG1 SITE GRADING PLAN

EP-1 ELECTRICAL ILLUMINATION PHOTOMETRIC STUDY EP-2 LUMINAIRE AND POLE SPECIFICATIONS

DE1 DETAILS AND NOTES

LEGEND

ITEM PROPERTY LINE	EXISTING	PROPOSED
LOT LINE		
CENTERLINE		
EDGE OF ASPHALT		
CONCRETE CURB		
EDGE OF GRAVEL SHOULDER		
DITCH/DIRECTION OF FLOW		
DRAINAGE SWALE/DIRECTION OF FLOW		
WATERMAIN/SIZE	<u>150ø W/M</u>	150ø W/M
WATER SERVICE		
FIRE HYDRANT	-ф- <i>нүр</i>	→ HYD
EXISTING WATER VALVE	₩ w	₩ wv
CURB STOP VALVE	⊠ CSV	₩ CSV
WATERMAIN PLUG AND THRUST BLOCK		J
WATERMAIN BLOWOFF	_ BLOWOFF	o BLOWOFF
WATERMAIN REDUCER	٥	•
SANITARY SEWER/SIZE/DIRECTION OF FLOW	200ø_ SAN	200ø SAN
SANITARY MAINTENANCE HOLE	○ SAN MH	SAN MH
SANITARY SERVICE	—·—·—·—	
SANITARY FORCEMAIN		
STORM SEWER/SIZE/DIRECTION OF FLOW	375ø_STM	375ø STM
STORM MAINTENANCE HOLE	→ STM MH	● STM MH
CATCH BASIN		■ CB4
DOUBLE CATCH BASIN		■ DCB4
CATCH BASIN MAINTENANCE HOLE	<u></u> СВМН	□ CBMH4
DOUBLE CATCH BASIN MAINTENANCE HOLE	© DCBMH	⊕ DCBMH4
DITCH INLET CATCH BASIN		
	□ <i>DICB</i>	■ DICB4
CULVERT		
BELL UNDERGROUND	——————————————————————————————————————	———— BU ———————————————————————————————
BELL AERIAL	CU	cu
CABLE UNDERGROUND	CO	CA
CABLE AERIAL	——————————————————————————————————————	
HYDRO UNDERGROUND		
HYDRO AERIAL	——————————————————————————————————————	—— на ——
GAS MAIN/SERVICE	——— GAS ———	GAS
FENCE	— x — x —	— x — x —
GUIDERAIL		
BUSHLINE/TREELINE	170.00	170.00
CONTOUR	179.00	179.00
SPOT ELEVATION	× 179.00 	×179.00 1.9%_
GRADING DIRECTION/GRADE PERCENTAGE		4-
DRAINAGE FLOW	h ann	h alau
TRAFFIC SIGN	Þ SIGN	► SIGN
TRAFFIC POLE/TRAFFIC SIGNAL	OTLS	● P1
LIGHT STANDARD	O <i>LS</i>	• LS
HYDRO POLE	O HP	• HP
GUY WIRE	> —	>
BELL POLE	0 <i>BP</i>	
BELL MAINTENANCE HOLE	○ BELL MH	
BELL PEDESTAL/VAULT	B	
CABLE PEDESTAL/VAULT		
HYDRO TRANSFORMER/VAULT	oxdot	
GAS VALVE	GAS VALVE	
GAS MARKER	⊕ ^{GAS}	
MAILBOX	M	
STANDARD IRON BAR	- ‡ - SIB	
RON BAR	■ //B	
TEMPORARY BENCHMARK	● <i>TBM#1</i>	
BOREHOLE/TEST HOLE	⊕ BH9	
DECIDUOUS/CONIFEROUS TREE, SHRUB/BUSH		

DISCLAIMER AND COPYRIGHT

CONTRACTOR MUST VERIFY ALL DIMENSIONS AND BE RESPONSIBLE FOR SAME. ANY DISCREPANCIES MUST BE REPORTED TO THE ENGINEER BEFORE COMMENCING WORK. DRAWINGS ARE NOT TO BE

TATHAM ENGINEERING LIMITED CLAIMS COPYRIGHT TO THIS DRAWING WHICH MAY NOT BE USED FOR ANY PURPOSE OTHER THAN THAT PROVIDED IN THE CONTRACT BETWEEN THE OWNER/CLIENT AND THE ENGINEER WITHOUT THE EXPRESS CONSENT OF

BENCHMARKS TBM1 - ELEVATION 181.10

ENGINEERI NAIL IN HYDRO POLE LOCATED TO THE NORTHWEST OF THE NORTH CORNER OF THE SITE. LEGAL SUI 13, 2024.

NOTES	No.	REVISION DESCRIPTION	DATE
TOPOGRAPHIC SURVEY COMPILED BY TATHAM ENGINEERING LIMITED DATED JANUARY 6, 2023.	1.	FIRST ENGINEERING SUBMISSION	APR 2024
LEGAL SURVEY BY MEASEARTH INC., DATED AUGUST 13, 2024.	2.	SECOND ENGINEERING SUBMISSION	SEP 2024
SITE PLAN BASED ON CONCEPT SITE PLAN PREPARED			
BY GERRARD'S DESIGN AND DRAFTING INC. DATED DECEMBER 11, 2023			

ENGINEER STAMP



10045 HIGHWAY 26 **COMMERCIAL DEVELOPMENT**


TOWNSHIP OF COLLINGWOOD

INDEX PLAN




IN-1

DESIGN: AO/KRL FILE: 122093 DRAWN: KRL DATE: MAR 2024 CHECK: AO SCALE: NTS

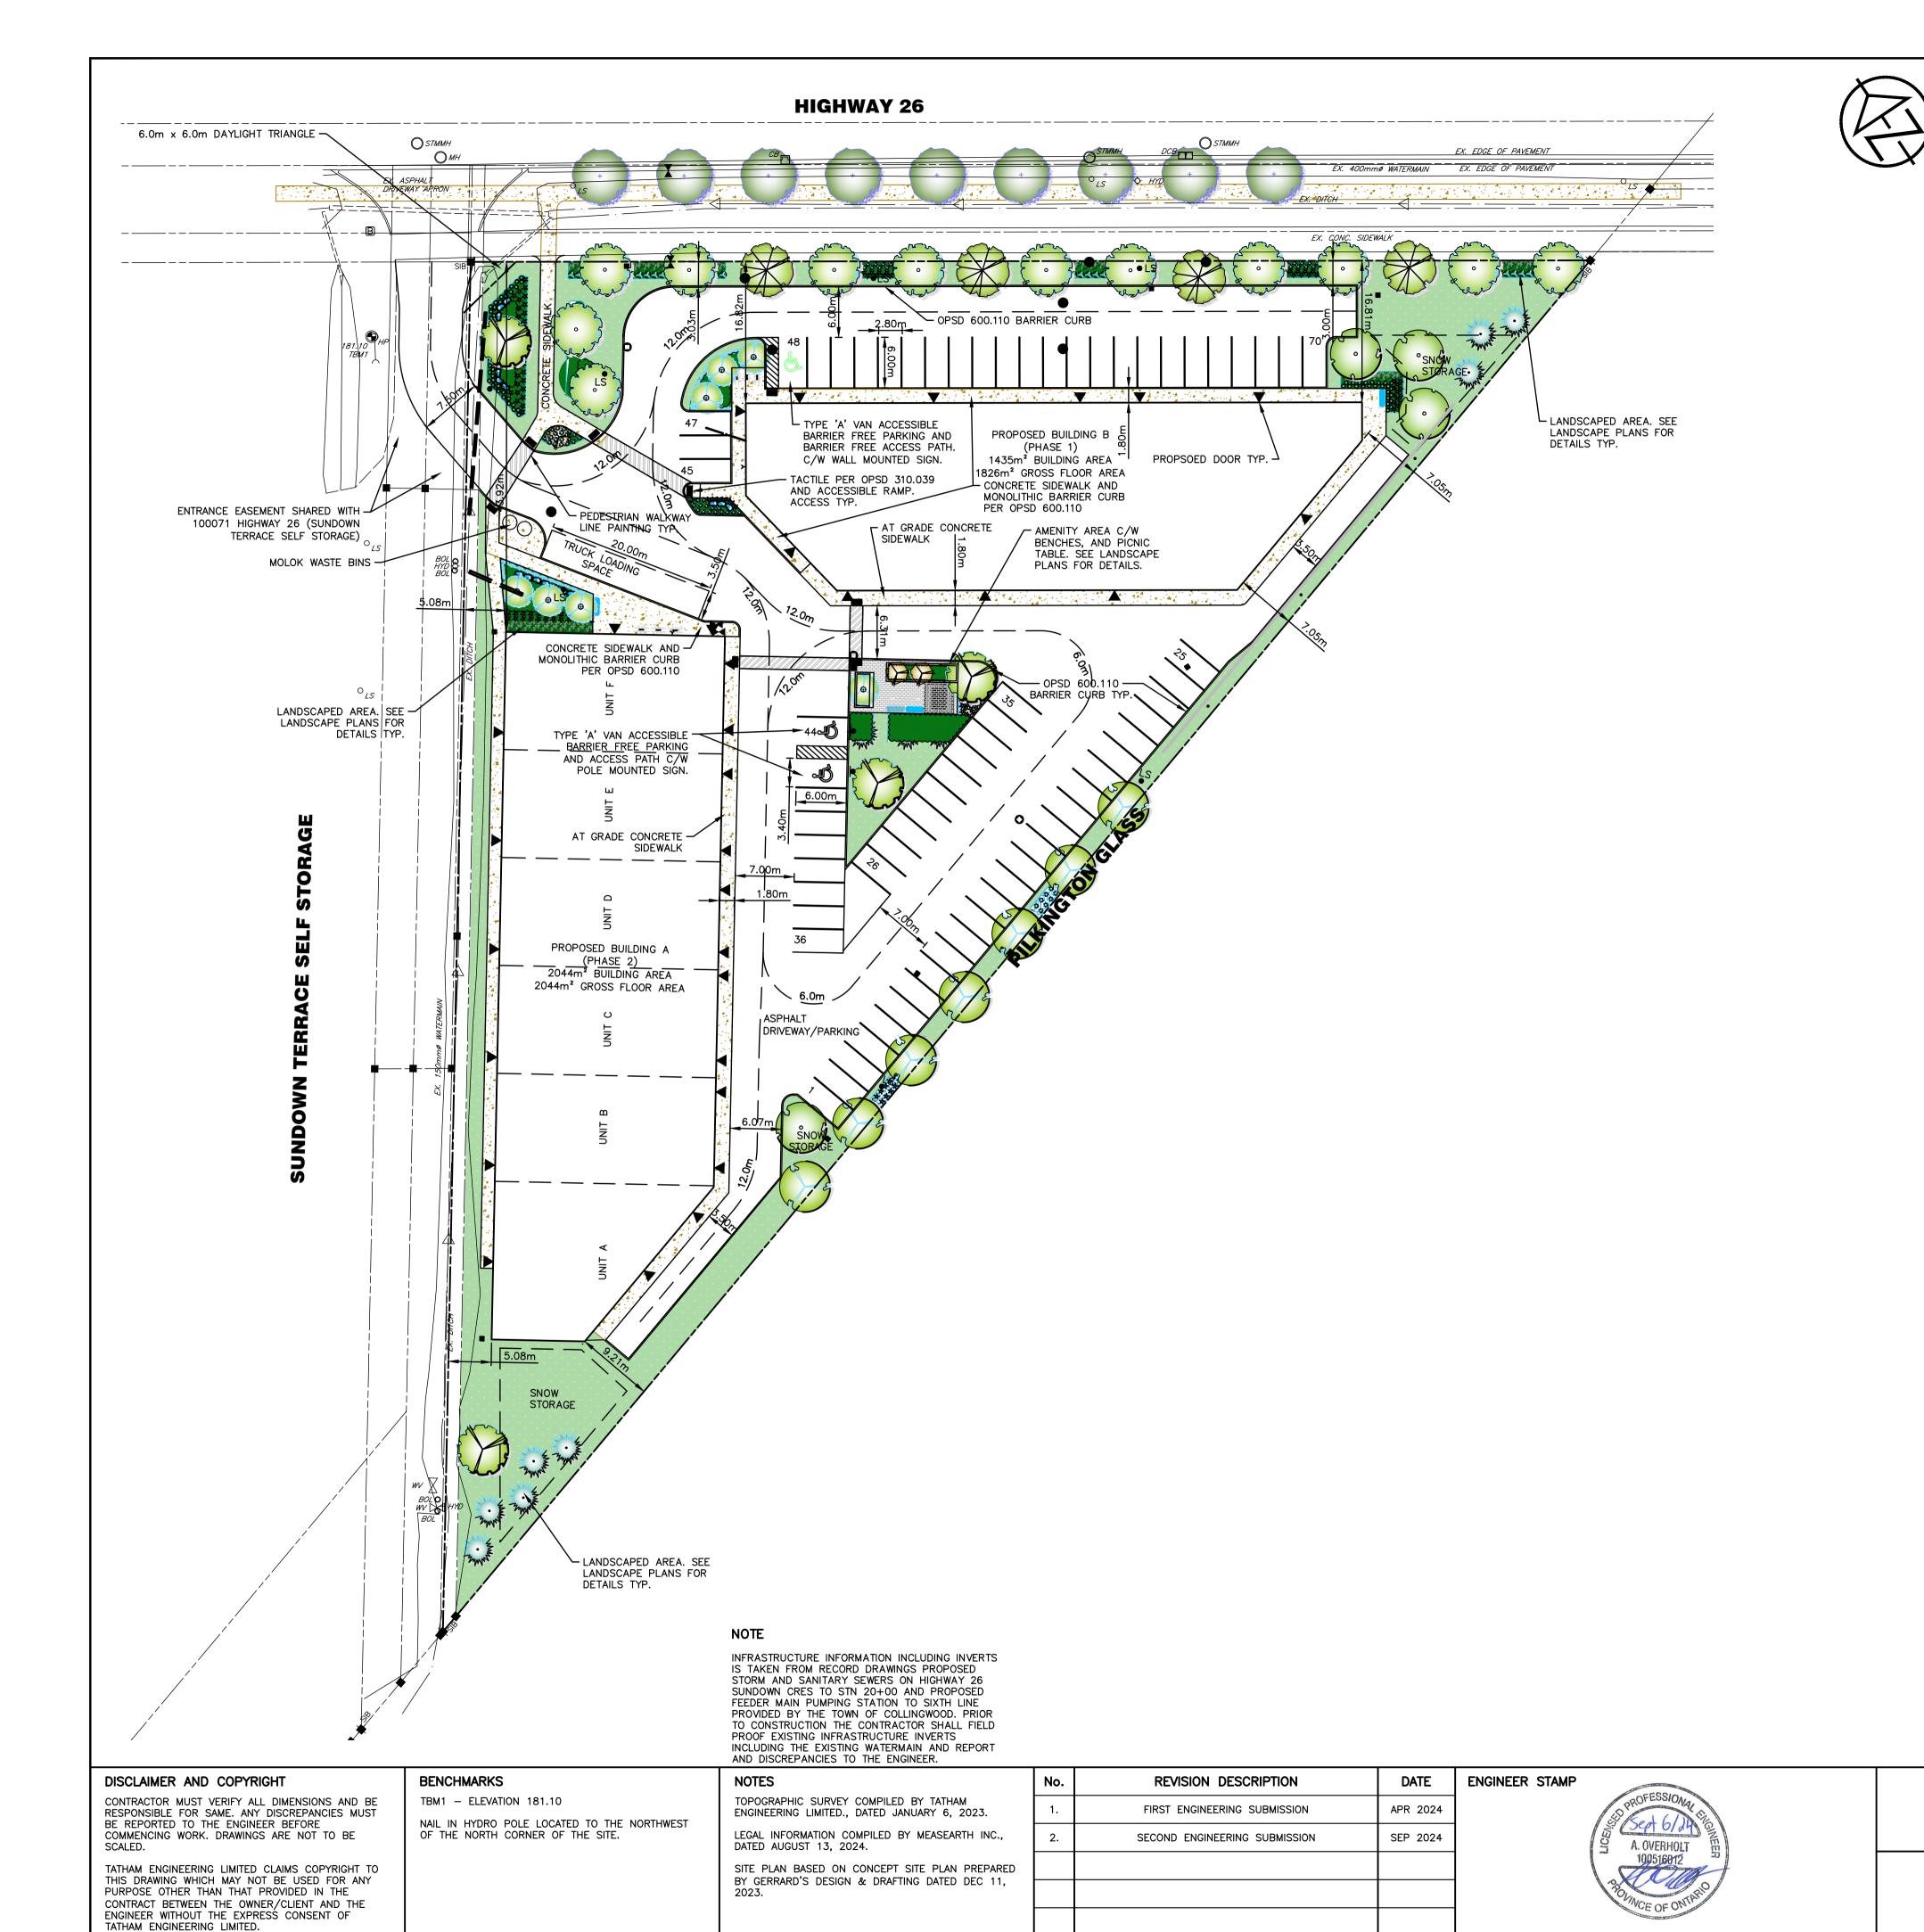

Drawing Name: 122093-SP-1.dwg, Plotted: Sep 06, 2024

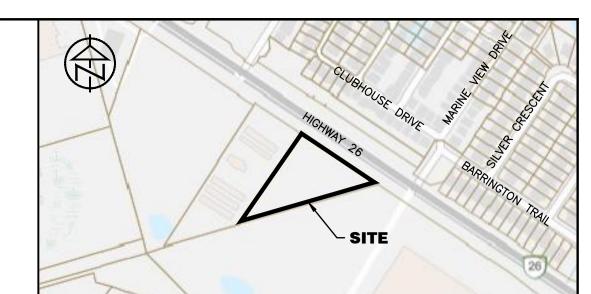

KEY PLAN

M1 ZONE	REQUIRED	PROVIDED
MINIMUM LOT AREA MINIMUM LOT FRONTAGE MINIMUM FRONT YARD MINIMUM INTERIOR SIDE YARD MINIMUM INTERIOR SIDE YARD MINIMUM REAR YARD MAXIMUM LOT COVERAGE MINIMUM LANDSCAPED OPEN: AMMENITY AREA MAX. BUILDING HEIGHT BUILDING AREA GROSS FLOOR AREA (GFA) PARKING: BUILDING A W.	30m 9m (WEST) 4.5m (EAST) 4.5m 7.5m 50%	7.05m N/A 32% 21% 80m ²
BUILDING B OT		DING AREA ON SITE
	PACE/ 100m² x 2044m PACES/ 100m² x 1826	
76 SPACES REQUIRED OF WHI	CH 3 ARE TO BE ACC	ESSIBLE.
70 SPACES PROVIDED INCLUD	ING 3 ACCESSIBLE (VA	RIANCE REQUIRED).
LOADING SPACE 1 SF BIKE PARKING 10%	PACE 1 REQ OF PARKING 7 REQ	UIRED 1 PROVIDED



RB-93 SIGN NTS



TOWN APPROVAL

SITE PLAN

10045 HIGHWAY 26 DEVELOPMENT TOWNSHIP OF COLLINGWOOD


DRAWN: KRL

DESIGN: AO/KRL FILE: 122093 DATE: MAR 2024 SCALE: 1:400 CHECK: AO

SP-1





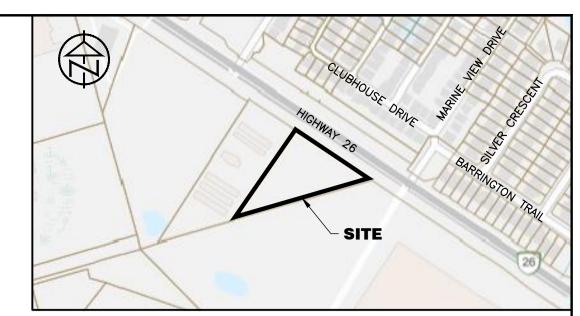

KEY PLAN

TOWN APPROVAL

CONTRACTOR MUST VERIFY ALL DIMENSIONS AND BE RESPONSIBLE FOR SAME. ANY DISCREPANCIES MUST BE REPORTED TO THE ENGINEER BEFORE COMMENCING WORK. DRAWINGS ARE NOT TO BE

TATHAM ENGINEERING LIMITED CLAIMS COPYRIGHT TO THIS DRAWING WHICH MAY NOT BE USED FOR ANY PURPOSE OTHER THAN THAT PROVIDED IN THE CONTRACT BETWEEN THE OWNER/CLIENT AND THE ENGINEER WITHOUT THE EXPRESS CONSENT OF TATHAM ENGINEERING LIMITED.

Drawing Name: 122093—TRK—1.dwg, Plotted: Sep 06, 2024

LEGAL INFORMATION COMPILED BY MEASEARTH INC., DATED AUGUST 13, 2024. SITE PLAN BASED ON CONCEPT SITE PLAN PREPARED BY GERRARD'S DESIGN & DRAFTING DATED DEC 11, 2023.

	No.	REVISION DESCRIPTION	DATE
	1.	FIRST ENGINEERING SUBMISSION	APR 2024
	2.	SECOND ENGINEERING SUBMISSION	SEP 2024
D			




10045 HIGHWAY 26 DEVELOPMENT TOWNSHIP OF COLLINGWOOD


TRUCK TURNING TEMPLATE


	Т	- /	4			\vdash	1	A	1	\wedge
	E	N	G	1	N	E	E	R	1	N

DESIGN: AO/KRL FILE: 122093 DRAWN: KRL DATE: JUL 2024 CHECK: AO SCALE: 1:400


TRK-1

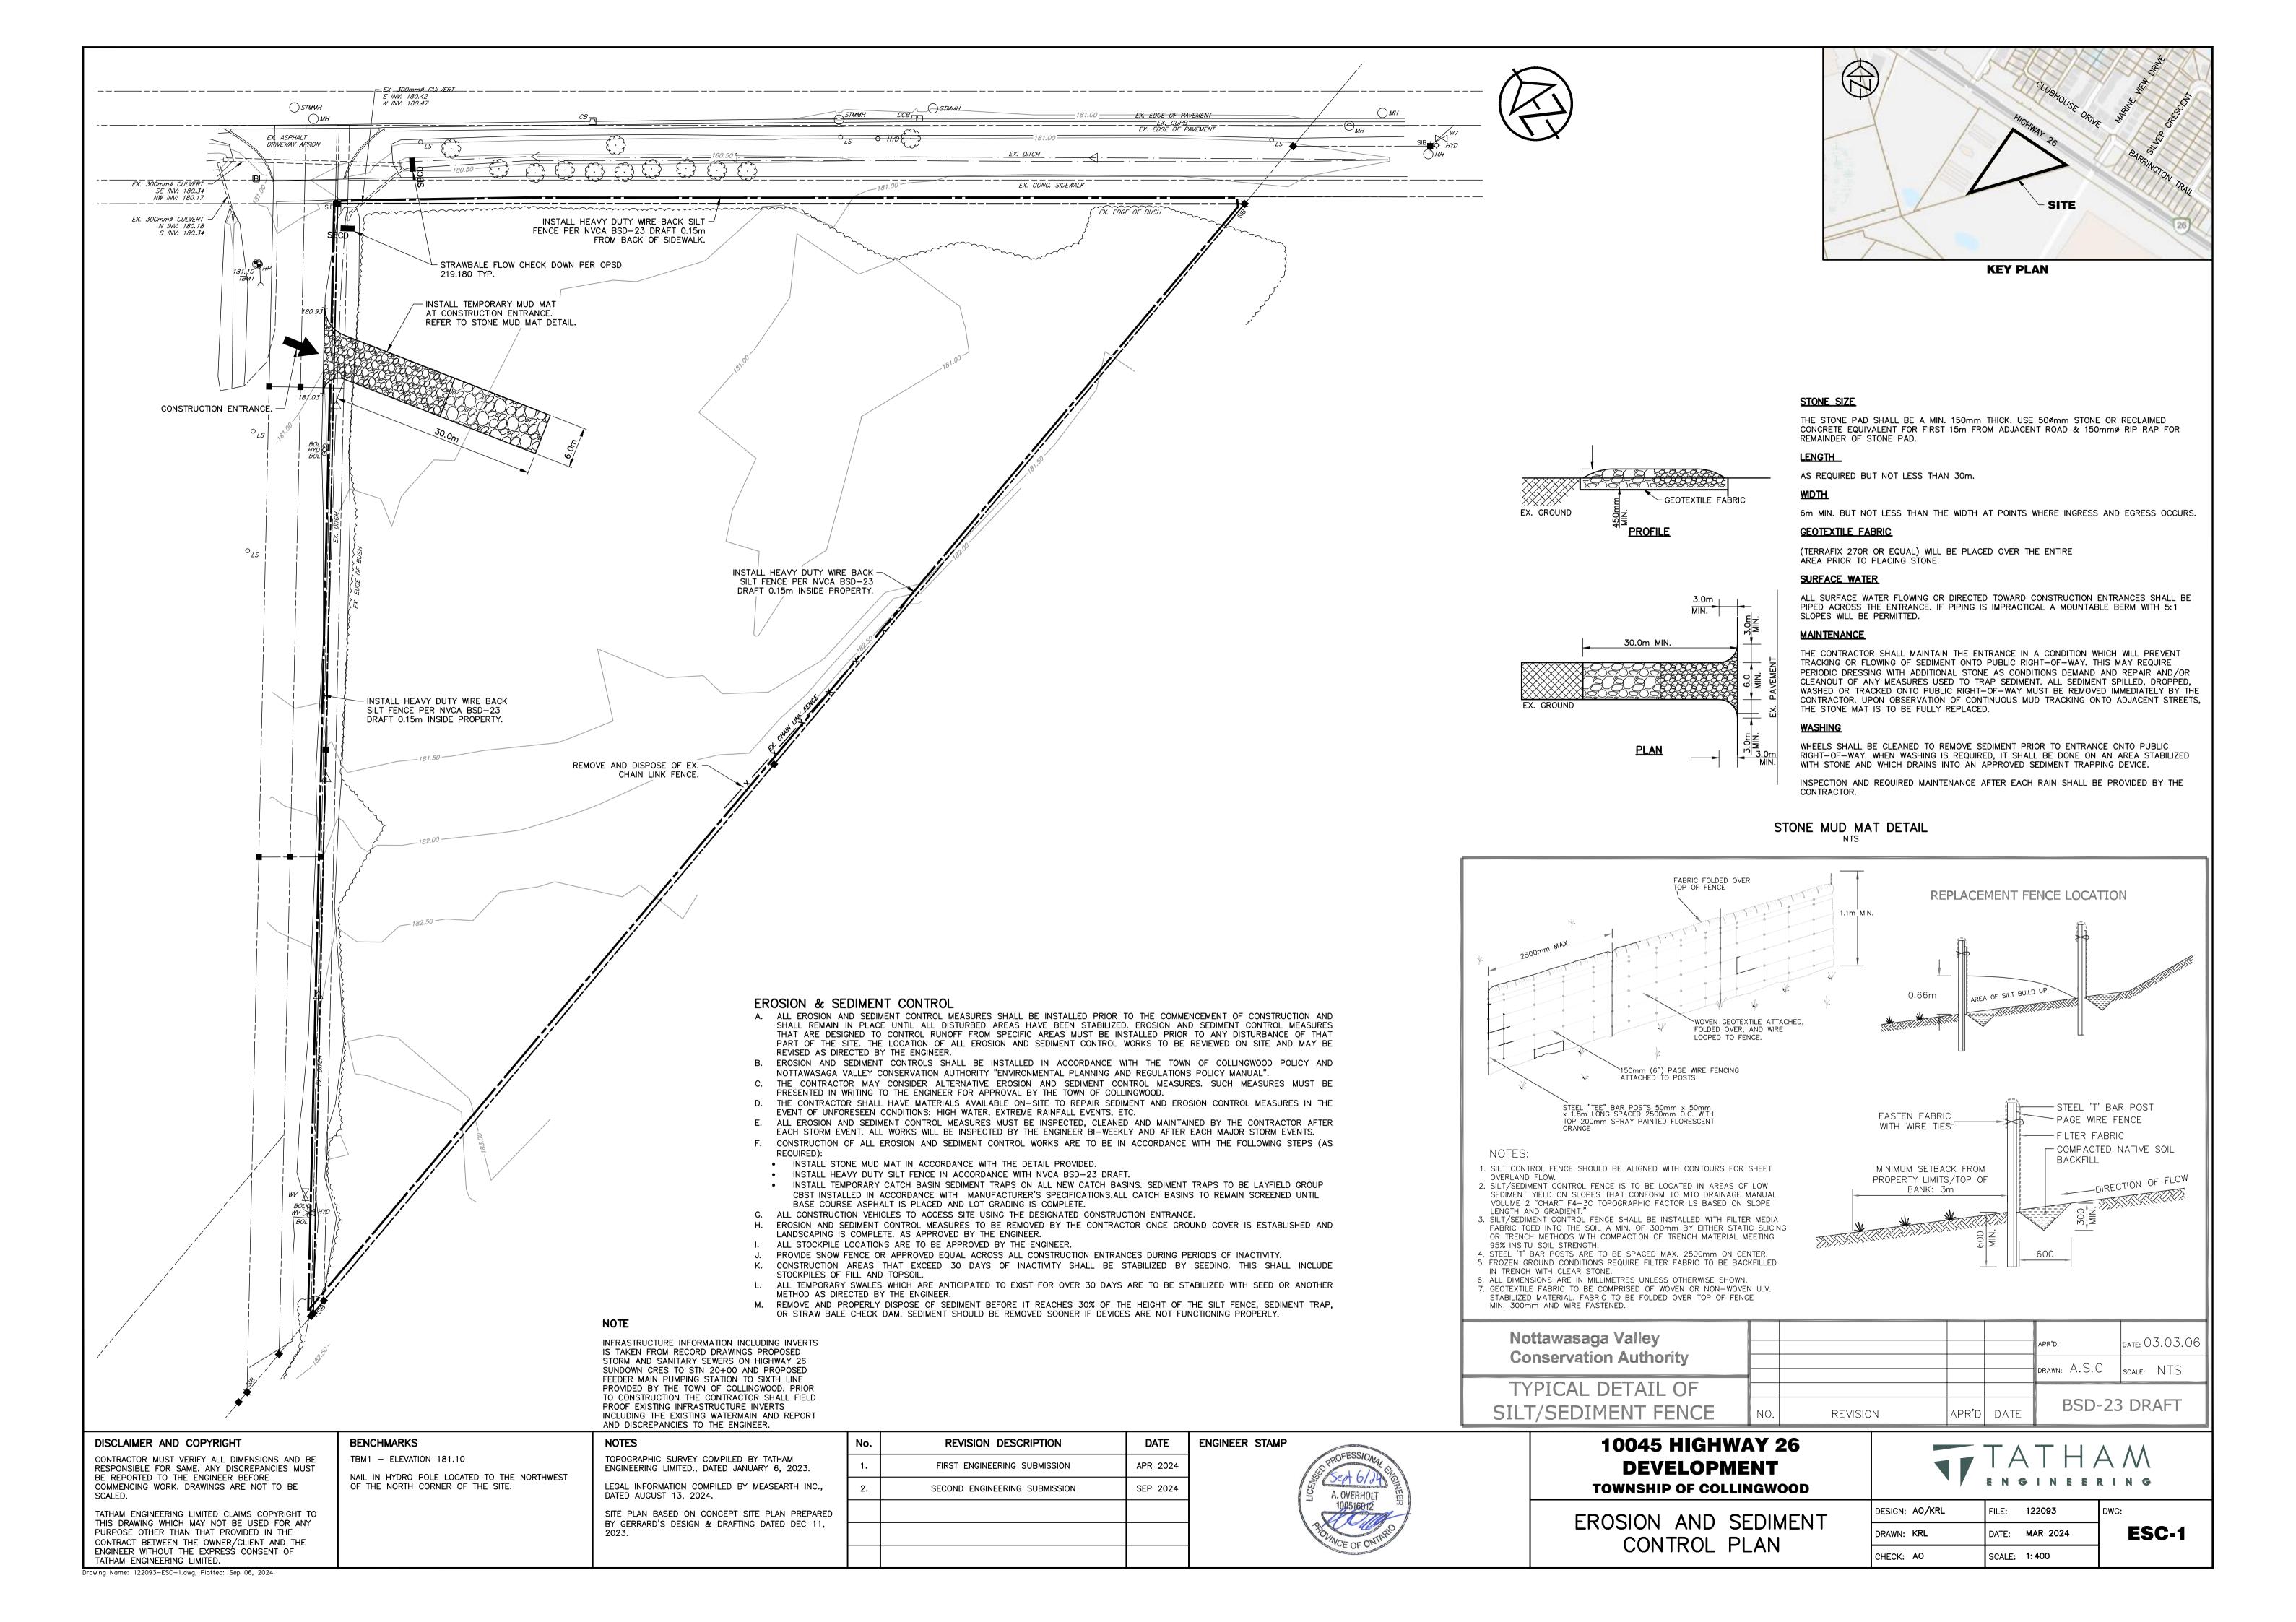

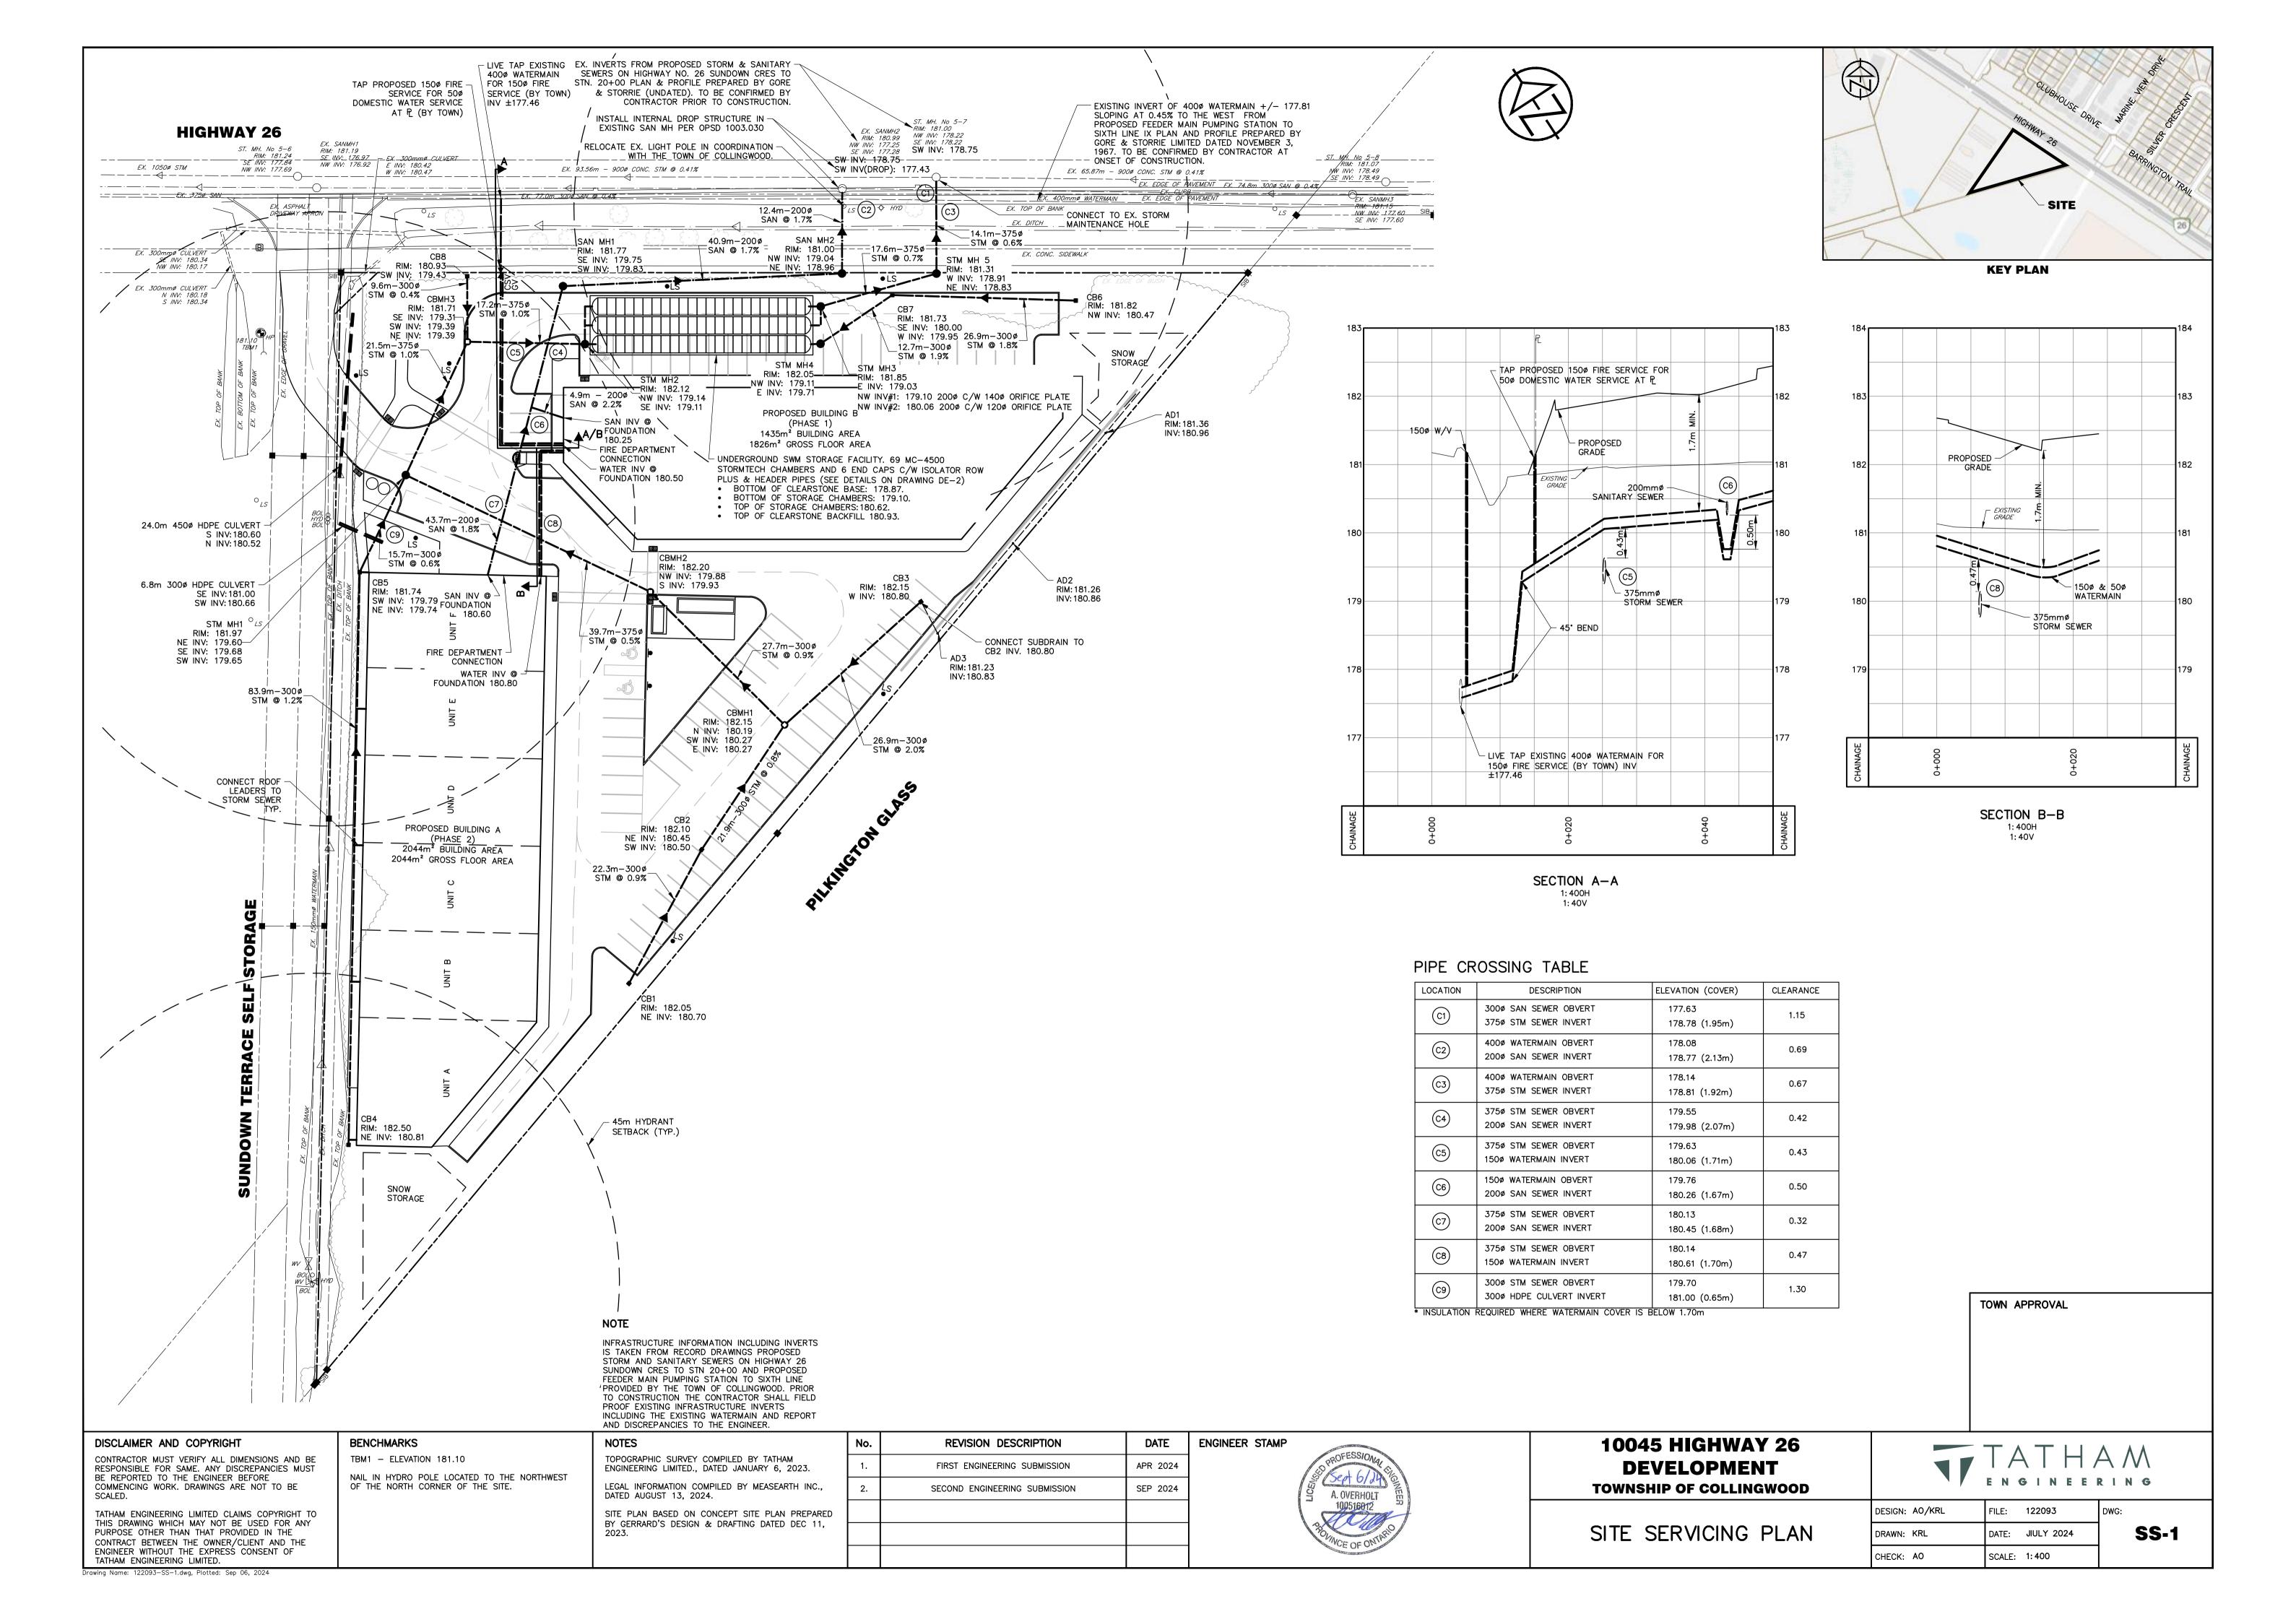

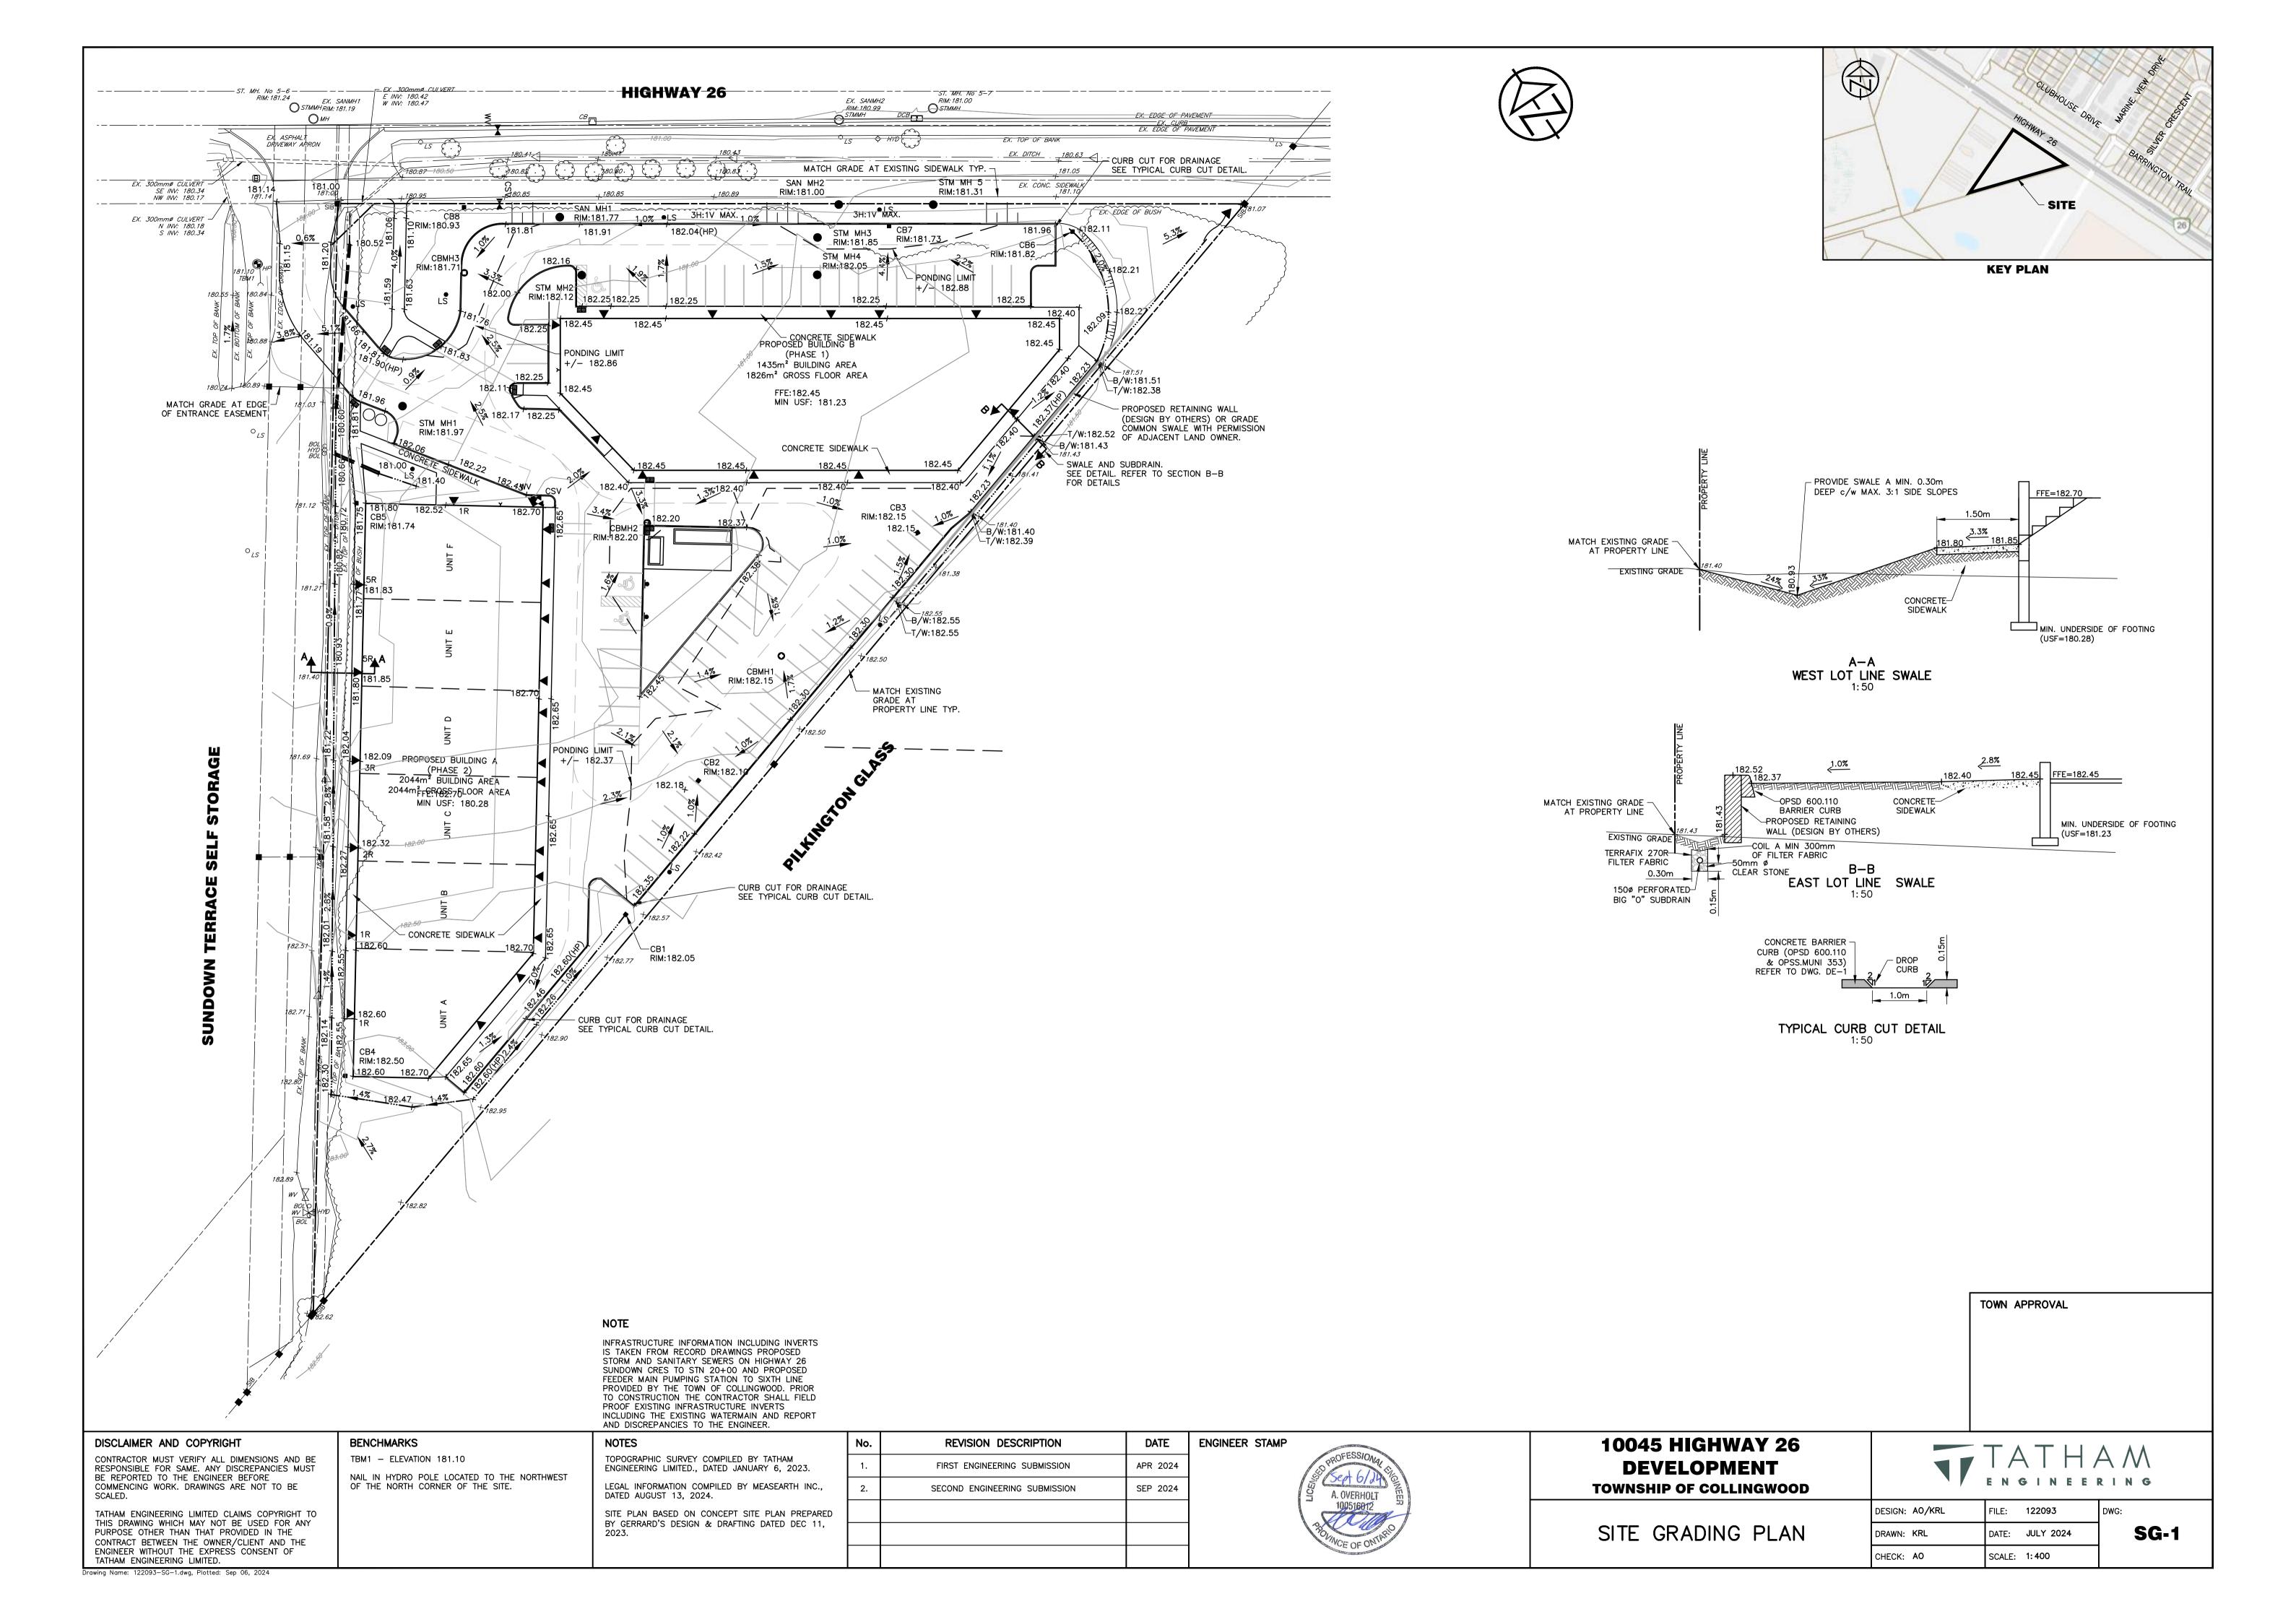



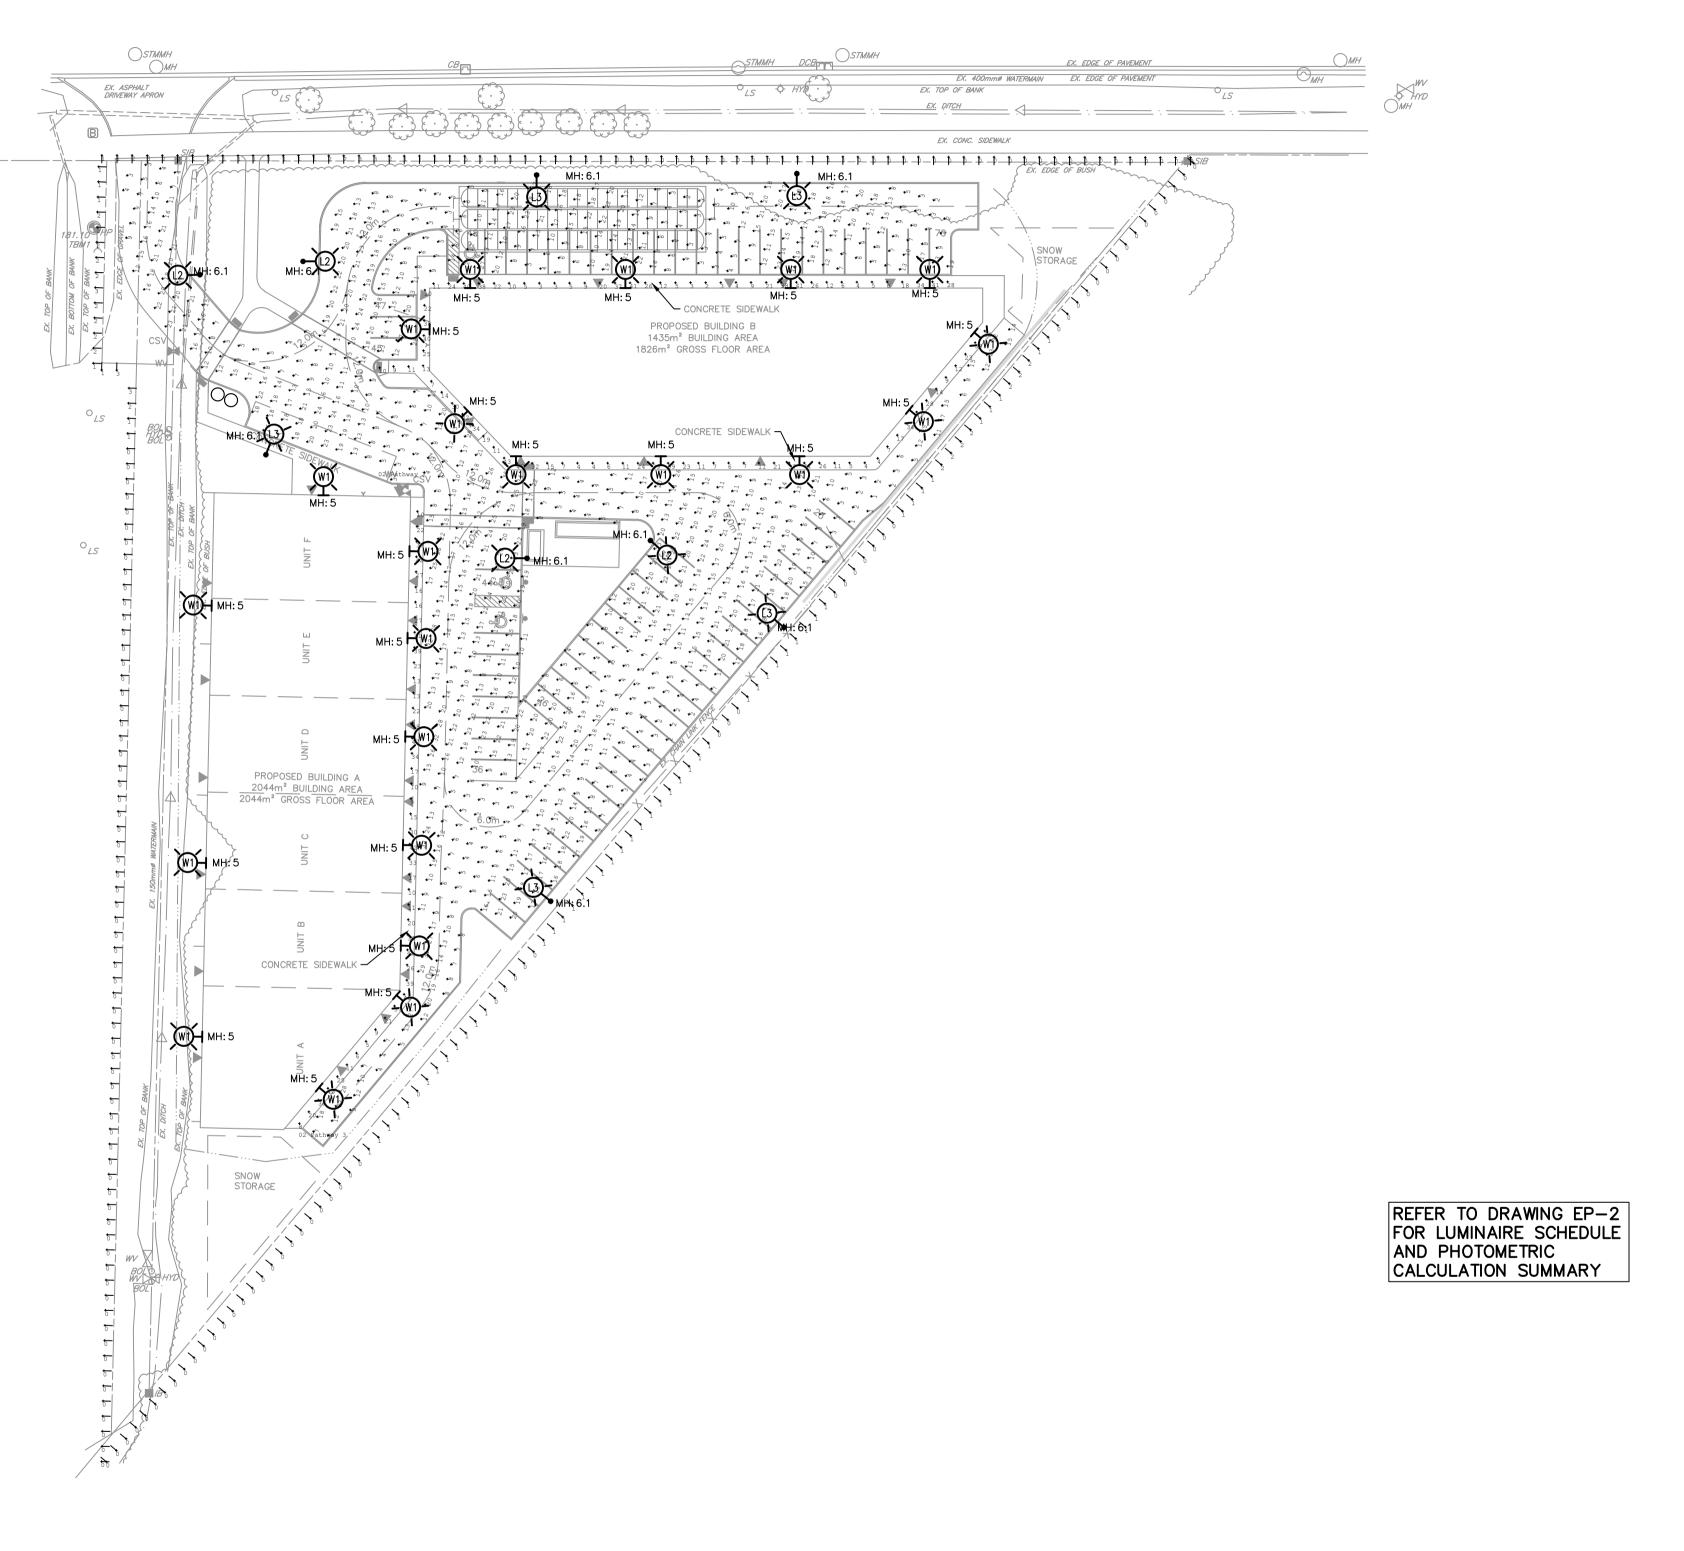

SITE PLAN PHOTOMETRIC ILLUMINATION STUDY (ILLUMINATION LEVELS SHOWN IN LUX)

• SCALE 1:500


DISCLAIMER AND COPYRIGHT CONTRACTOR MUST VERIFY ALL DIMENSIONS AND BE RESPONSIBLE FOR SAME. ANY DISCREPANCIES MUST BE REPORTED TO THE ENGINEER BEFORE COMMENCING WORK. DRAWINGS ARE NOT TO BE SCALED.

TATHAM ENGINEERING LIMITED CLAIMS COPYRIGHT TO
THIS DRAWING WHICH MAY NOT BE USED FOR ANY
PURPOSE OTHER THAN THAT PROVIDED IN THE
CONTRACT BETWEEN THE OWNER/CLIENT AND THE
ENGINEER WITHOUT THE EXPRESS CONSENT OF
TATHAM ENGINEERING LIMITED

BENCHMARKS

NOTES

REVISION DESCRIPTION ENGINEER STAMP APRIL 2024 1ST SUBMISSION

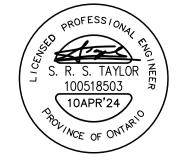


10045 HIGHWAY 26 DEVELOPMENT TOWN OF COLLINGWOOD

ELECTRICAL ILLUMINATION PHOTOMETRIC STUDY

1	\top	- /	Δ				-	\wedge	1	Λ	\wedge	
	E	N	G	ı	N	E	E	R	1	N	G	

DESIGN: PP/SRT FILE: 122093 DRAWN: PP DATE: MARCH 2024 CHECK: SRT SCALE: AS SHOWN

EP-1

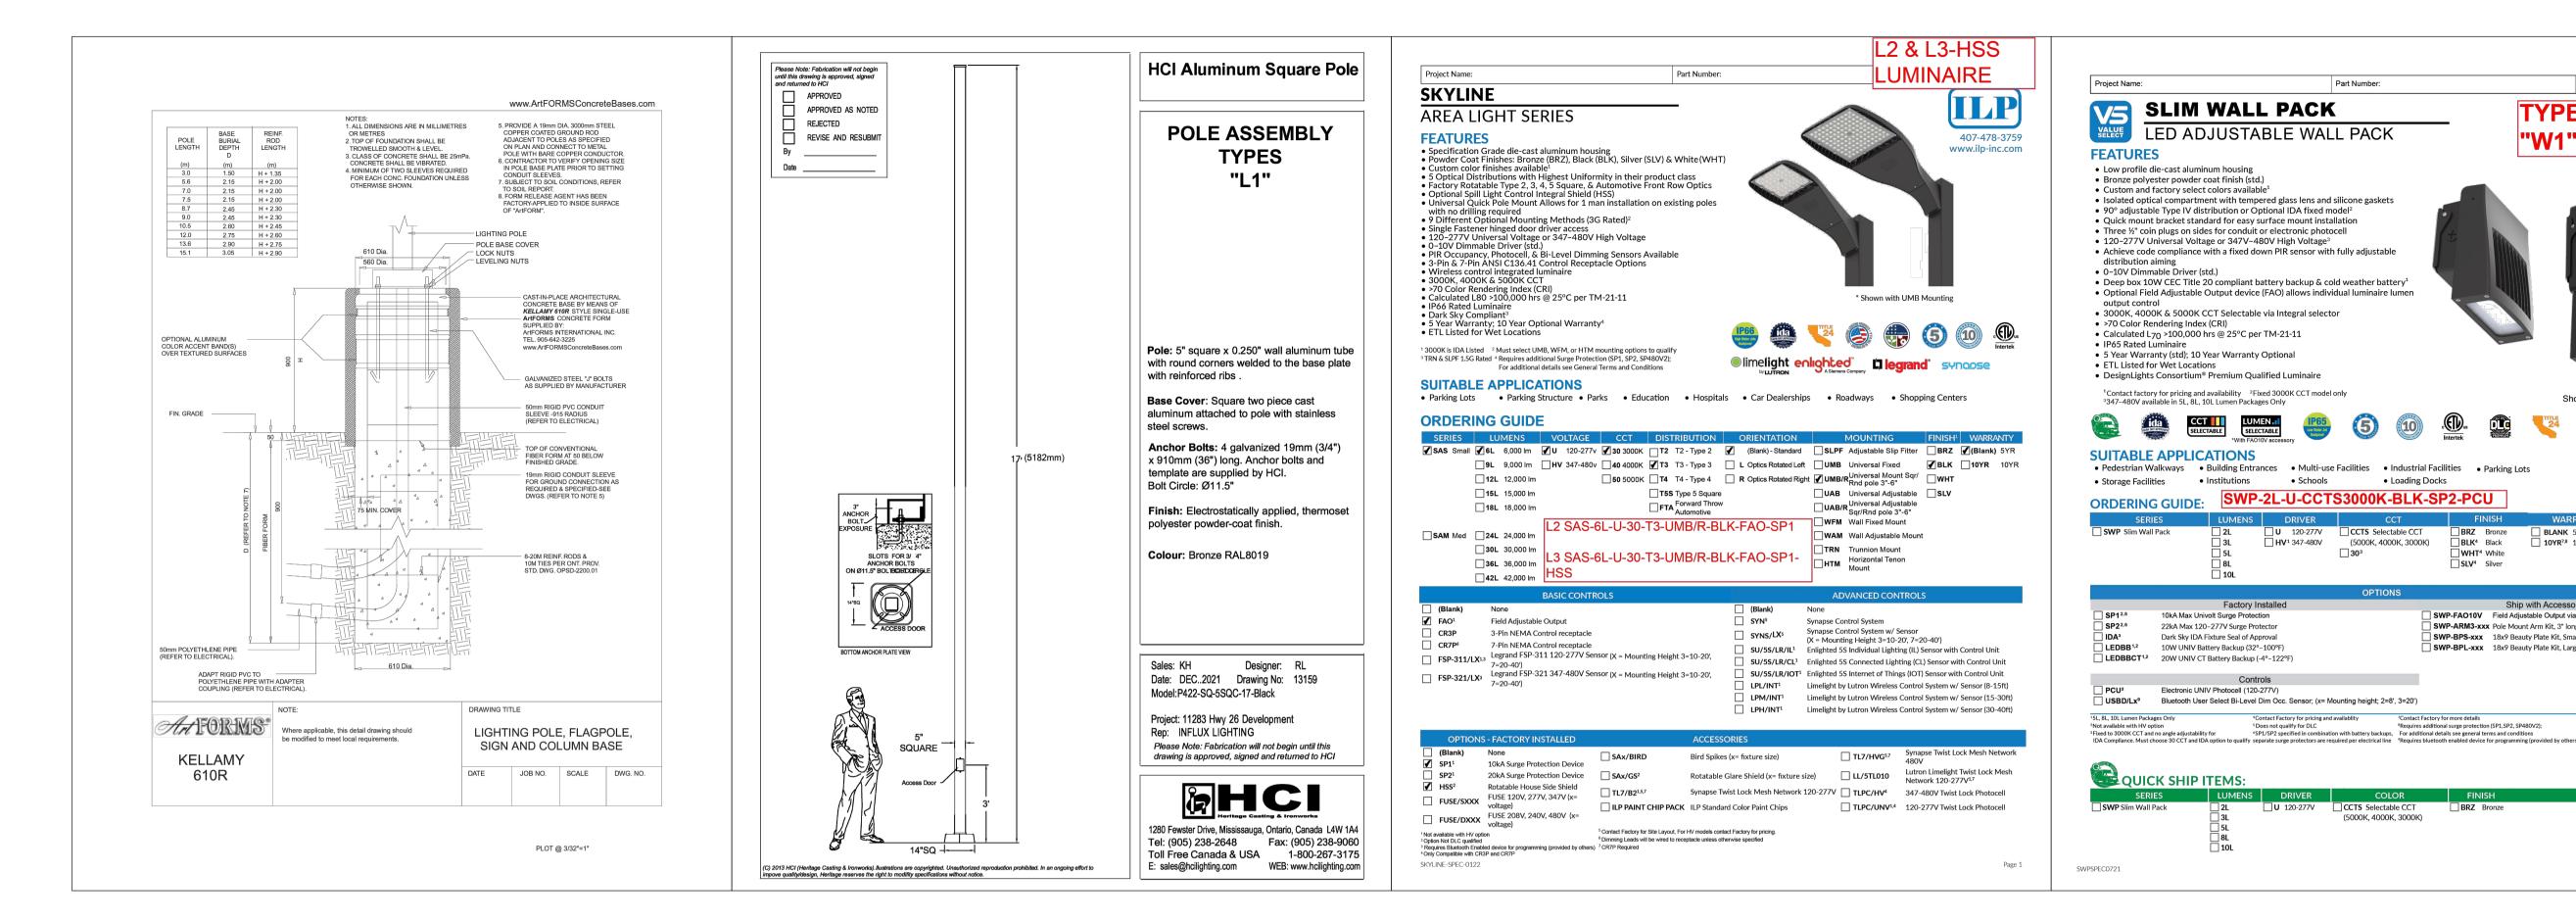

POLE, POLE BASE AND LUMINAIRE SPECIFICATIONS (ALL LUMINAIRES IDA DARK SKY COMPLIANT)

• N.T.S.

Lumir	Luminaire Schedule					
Qty	Label	Description	LLF	Luminaire Lumens	Luminaire Watts	
22	W1 HWI	SWP-2L-U-40-BRZ	0.950	2649	19	
5	L2 • L2	SAS-6L-U-30-T3	0.950	6302	45.8	
5	L3-HSS • L3	SAS-6L-U-30-T3-HSS	0.950	4311	45.8	

Calculation Summary							
Label	CalcType	Units	Avg	Max	Min	Avg/Min	Max/Min
01 Parking	Illuminance	Lux	12.9	35	1	N.A.	35.0
02 Pathway 1	Illuminance	Lux	4.0	6	1	4.0	N.A.
02 Pathway 2	Illuminance	Lux	19.3	47	2	9.6	N.A.
02 Pathway 3	Illuminance	Lux	24.7	47	5	5.0	N.A.
02 Pathway 4	Illuminance	Lux	11.2	22	2	5.6	N.A.
Property Vertical Spill Light	Illuminance	Lux	0.5	3	0	N.A.	N.A.

NOTES

REVISION DESCRIPTION ENGINEER STAMP 1ST SUBMISSION APRIL 2024

ANSI/IES RP-8 Recommendations

Table 17-2 Minimum Illuminance Criteria for Parking Areas Minimum Horizontal: 2 Lux

Uniformity Ratio Max. (Max / Min): 20:1

Table 4-2 Recommended Maximum Vertical Illuminace Spill Light Lighting Zone LZ-2

Maximum Vertical Illuminance: 3 Lux

IES RP8 RECOMMENDED TARGET ILLUMINATION CRITERIA

10045 HIGHWAY 26 DEVELOPMENT

TOWN OF COLLINGWOOD

LUMINAIRE AND POLE SPECIFICATIONS

17	Т	- /	Д			\vdash	-	A	1	\wedge	\bigwedge
	E	N	G	ı	N	E	E	R	1	N	G

407-478-3759

www.ilp-inc.com

Shown with Sensor Box

 U
 120-277V
 □ CCTS Selectable CCT
 □ BRZ
 Bronze

 HV¹ 347-480V
 (5000K, 4000K, 3000K)
 □ BLK⁴
 Black

U 120-277V CCTS Selectable CCT

10kA Max Univolt Surge Protection

22kA Max 120-277V Surge Protector

10W UNIV Battery Backup (32°-100°F)

Electronic UNIV Photocell (120-277V)

WHT⁴ White

SWP-FAO10V Field Adjustable Output via 0-10V Wires

SWP-ARM3-xxx Pole Mount Arm Kit, 3" long (xxx=BRZ, BLK, WHT, SLV)

SWP-BPS-xxx 18x9 Beauty Plate Kit, Small (xxx=BRZ, BLK, WHT, SLV)

SWP-BPL-xxx 18x9 Beauty Plate Kit, Large (xxx=BRZ, BLK, WHT, SLV)

DESIGN: PP/SRT FILE: 122093 DATE: MARCH 2024 DRAWN: PP CHECK: SRT SCALE: AS SHOWN

EP-2


TATHAM ENGINEERING LIMITED.

LUMINAIRE SCHEDULE AND CALCULATION SUMMARY

BENCHMARKS

DISCLAIMER AND COPYRIGHT CONTRACTOR MUST VERIFY ALL DIMENSIONS AND BE RESPONSIBLE FOR SAME. ANY DISCREPANCIES MUST BE REPORTED TO THE ENGINEER BEFORE COMMENCING WORK. DRAWINGS ARE NOT TO BE

TATHAM ENGINEERING LIMITED CLAIMS COPYRIGHT TO THIS DRAWING WHICH MAY NOT BE USED FOR ANY PURPOSE OTHER THAN THAT PROVIDED IN THE CONTRACT BETWEEN THE OWNER/CLIENT AND THE ENGINEER WITHOUT THE EXPRESS CONSENT OF

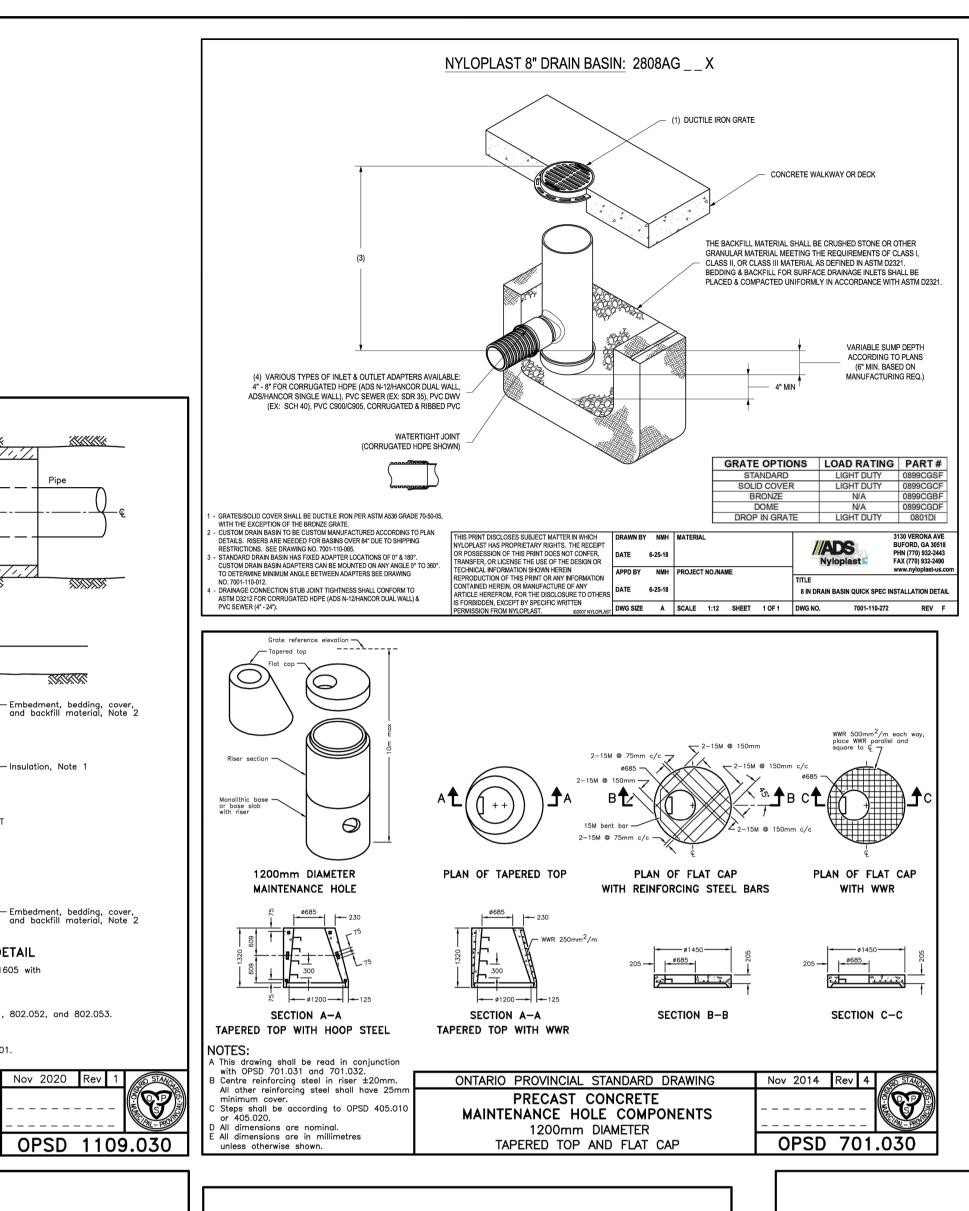



 Dropped curb at entrances

Thickness of

sidewalk

OPSD 600.110

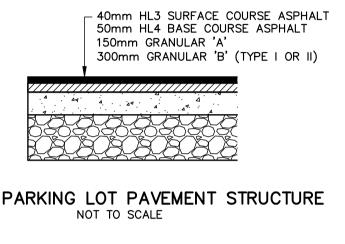

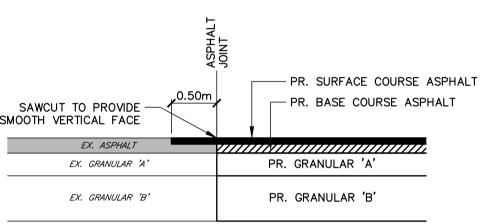

LAP JOINT DETAIL NOT TO SCALE

_ _ _ _ _ _ _ _


DATE

APR 2024

SEP 2024

OPSD 705.010

ASPHALT PARKING LOT PAVEMENT STRUCTURE

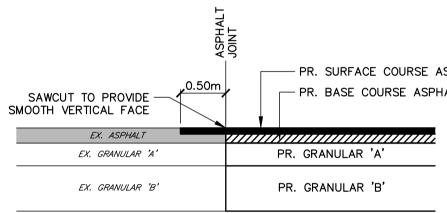

- 300mm maximum fron sewer invert to first strap clearance — – 45° wye cleanout, optiona FRONT VIEW SIDE VIEW steel strap. Typ - Maintenance MAINTENANCE HOLE IN SECTION -PVC drop pipe ✓ Note 1 6x40mm stainless

FASTENER DETAIL

BENCHMARKS

TBM1 - ELEVATION 181.10

OF THE NORTH CORNER OF THE SITE.

NAIL IN HYDRO POLE LOCATED TO THE NORTHWEST

INTERNAL DROP STRUCTURE DETAIL

Existing benching

= thickness of insulation

a minimum compressive strength of 275 kPa.

A Minimum insulation thickness shall be 50mm.

Profile grade -

Subarade

PLAN

SECTION A-A

TYPICAL PIPE INSULATION DETAIL

1 The insulation material shall be extruded polystyrene according to OPSS 1605 with

b) Rigid - OPSD 802.030, 802.031, 802.032, 802.033, 802.050, 802.051, 802.052, and 802.053.

2 Pipe embedment or bedding, cover, and backfill shall be according to:

C This OPSD is to be read in conjunction with OPSD 3090.100 and 3090.101.

ONTARIO PROVINCIAL STANDARD DRAWING

INSULATION FOR

SEWERS AND WATERMAINS

IN SHALLOW TRENCHES

a) Flexible OPSD 802.010, 802.013, 802.020, and 802.023.

B Joints shall be staggered for multiple insulation sheets.

D All dimensions are in millimetres unless otherwise shown

NOTES:

1 At the elbow, a stainless steel strap is required at bottom of bell. A Internal drop structure shall be used on existing maintenance holes 1500mm diameter and larger with a minimum height of 600mm from the inlet pipe invert to the top of benching. The existing benching shall be modified as required.

3 Drop pipe shall be one size smaller than the incoming sewer with a minimum 150mm

diameter and maximum of 375mm diameter. A maximum of 300mm diameter for

1500mm maintenance holes. Straps shall not be placed within 150mm of any maintenance hole section joint. D All dimensions are in millimetres unless otherwise shown.

ONTARIO PROVINCIAL STANDARD DRAWING INTERNAL DROP STRUCTURE FOR EXISTING MAINTENANCE HOLES _ _ _ _ _ _ _ _

Nov 2021 Rev 5 OPSD 1003.030 WITH OPTIONAL SIDE CLEANOUT

a minimum length of 3.0m, except in conjunction with guide rail where it shall be according to the OPSD 900 Series. D All dimensions are in millimetres unless otherwise shown. Nov 2012 Rev 2 ONTARIO PROVINCIAL STANDARD DRAWING CONCRETE BARRIER CURB

TOPOGRAPHIC SURVEY COMPILED BY TATHAM

ENGINEERING LIMITED DATED JANUARY 6, 2023.

LEGAL SURVEY BY MEASEARTH INC., DATED AUGUST

SITE PLAN BASED ON CONCEPT SITE PLAN PREPARED

BY GERRARD'S DESIGN AND DRAFTING INC. DATED

1 When sidewalk is continuously adjacent, the dropped curb

A Treatment at entrances shall be according to OPSD 351.010.

B Outlet treatment shall be according to the OPSD 610 Series.

2 For slipforming procedure a 5% batter is acceptable.

C The transition from one curb type to another shall be

NOTES

13, 2024.

DECEMBER 11, 2023

at entrances shall be reduced to 75mm.

150 ---

Note 2

is adjacent to curb

– 250 – –l 50 l-

Additional width when sidewalk

Finished road -

surface

ALTERNATE STANDARD HEIGHTS TERNATIVE DIMENSION 1980 В 1830 1520 D 1380 PLAN 600 --- 115 600 — ∠ Outlet ho all sides SECTION A-A SECTION B-B Outlet hole size 525mm diameter maximum, C Frame, grate, and adjustment units shall location as required. be installed according to OPSD 704.010. 200mm diameter knockout to accommodate Pipe support shall be according to OPSD 708.020. subdrain. Knockout shall be 60mm deep. E All dimensions are nominal. F All dimensions are in millimetres Centre reinforcing in base slab and walls unless otherwise shown. Granular backfill shall be placed to a minimum thickness of 300mm all around the catch basin. ONTARIO PROVINCIAL STANDARD DRAWING

PRECAST CONCRETE CATCH BASIN

600x600mm

REVISION DESCRIPTION

FIRST ENGINEERING SUBMISSION

SECOND ENGINEERING SUBMISSION

Nov 2019 Rev 4

- ALL DIMENSIONS ARE IN MILLIMETERS UNLESS OTHERWISE NOTED. B. ALL WORK SHALL BE CARRIED OUT IN ACCORDANCE WITH THE CURRENT TOWN OF COLLINGWOOD DEVELOPMENT STANDARDS, OPSS AND OPSD. WHERE
- INCONSISTENCY OCCURS, TOWN STANDARDS TO GOVERN. THE CONTRACTOR IS RESPONSIBLE FOR OBTAINING AN ENTRANCE PERMIT FROM THE TOWN PRIOR TO THE COMMENCEMENT OF CONSTRUCTION.
- THE OWNER'S ENGINEER SHALL PROVIDE BENCHMARK ELEVATIONS. THE
- CONTRACTOR SHALL BE RESPONSIBLE FOR THE DETAILED LAYOUT OF THE
- CONTRACTOR'S EXPENSE IF REMOVED DURING CONSTRUCTION. THE CONTRACTOR SHALL MAKE ARRANGEMENTS FOR THE SUPPLY OF TEMPORARY WATER AND POWER.
- DEWATERING SHALL BE CARRIED OUT IN ACCORDANCE WITH OPSS.MUNI 517 AND OPSS.MUNI 518. ALL TRENCHES SHALL BE MAINTAINED IN A DRY CONDITION. AN MECP PERMIT TO TAKE WATER (PTTW) HAS NOT BEEN OBTAINED FOR THIS
- H. ALL ENGINE DRIVEN PUMPS SHALL BE ADEQUATELY SILENCED, SUITABLE FOR OPERATION IN A RESIDENTIAL DISTRICT. GENERAL INSTALLATION AND TESTING OF SEWERS, WATERMAIN AND APPURTENANCES SHALL BE IN ACCORDANCE WITH TOWN STANDARDS AND
- FURTHER SUPPORTED AS NECESSARY BY OPSS 407, 408, 409 (CCTV), OPSS MUNI.410, OPSS.MUNI 421, AND OPSS.MUNI 441 AND ALL SPECIFICATIONS REFERENCED WITHIN THESE SECTIONS MINIMUM VERTICAL SEPARATION BETWEEN SEWERS AND WATERMAIN AT CROSSINGS SHALL BE 0.50 m. MINIMUM VERTICAL SEPARATION BETWEEN
- SEWERS AT CROSSINGS SHALL BE 0.15 m. K. ALL MAINTENANCE HOLES ARE 1,200 mm DIAMETER, UNLESS OTHERWISE
- SPECIFIED. DOUBLE CATCH BASIN MAINTENANCE HOLES ARE 1,500 mm DIAMETER, UNLESS OTHERWISE SPECIFIED.
- PIPE SUPPORT AT ALL STRUCTURES SHALL BE IN ACCORDANCE WITH OPSD M. ALL SANITARY AND STORM MAINTENANCE HOLES SHALL BE PROVIDED WITH
- FROST STRAPS. N. ALL MAINTENANCE HOLE AND CATCH BASIN FRAME AND GRATES SHALL BE SET TO BASE COURSE ASPHALT ELEVATION IN ACCORDANCE WITH OPSD 704.010. FRAME AND GRATES SHALL BE RAISED TO FINISHED GRADE PRIOR TO THE
- PLACEMENT OF SURFACE COURSE ASPHALT USING CONCRETE ADJUSTMENT UNITS. MAXIMUM COMBINED HEIGHT OF ADJUSTMENT UNITS SHALL BE 300 mm. TRENCH BACKFILL SHALL BE SELECT NATIVE MATERIAL AS APPROVED BY GEOTECHNICAL ENGINEER OR IMPORTED SELECT SUBGRADE MATERIAL TO OPSS 1010. BACKFILL TO BE PLACED IN MAXIMUM 200 mm THICK LIFTS (OR AS

A DRY DENSITY OF AT LEAST 95% OF THE MATERIAL'S STANDARD PROCTOR

- MAXIMUM DRY DENSITY (SPMDD). P. PIPE EMBEDMENT SHALL BE COMPACTED TO A DRY DENSITY OF AT LEAST 95% OF THE MATERIAL'S SPMDD. BACKFILL AND EMBEDMENT TO OPSD 802.010 (FLEXIBLE PIPE), GRANULAR 'A' EMBEDMENT OR OPSD 802.031 (RIGID PIPE) CLASS "B", GRANULAR 'A' BEDDING, GRANULAR 'B' COVER (MAX. AGGREGATE SIZE 25 mm). MINIMUM BEDDING DEPTH 150 mm, MINIMUM COVER DEPTH 300 mm ON ALL PIPES. WHERE EXCESSIVELY WET OR POOR SUBGRADE IS ENCOUNTERED AT THE INVERT LEVEL, IT MAY BE NECESSARY TO INCREASE THE BEDDING TYPE OR THICKNESS. BACKFILL AND EMBEDMENT SHALL BE IN ACCORDANCE WITH THE RECOMMENDATIONS OF THE GEOTECHNICAL REPORT AND
- OPERATIONS SHALL BE MONITORED BY A GEOTECHNICAL TECHNICIAN. CLEAR STONE COMPLETELY WRAPPED IN FILTER FABRIC MAY BE SUBSTITUTED FOR EMBEDMENT MATERIAL IF APPROVED BY THE ENGINEER. THE CONTRACTOR IS RESPONSIBLE FOR THE ENVIRONMENTAL QUALITY OF IMPORTED FILL AND SHALL PROVIDE A DOCUMENT TO CERTIFY THE MATERIAL IS FREE OF HAZARDOUS CONTAMINANTS. ALL MATERIALS SHALL ADHERE TO O.
- DISTURBED AREAS SHALL BE REINSTATED TO PREVIOUS CONDITION OR BETTER. REINSTATEMENT OF ALL BOULEVARDS AND DITCHES SHALL INCLUDE FINE GRADING, PLACEMENT OF MINIMUM 150 mm TOPSOIL AND NURSERY SOD IN ACCORDANCE WITH OPSS 802, OPSS 803 AND OPSS.MUNI 804. SOD SHALL BE
- STAKED WHERE NECESSARY TO AVOID MOVEMENT. TRAFFIC MARKERS AND SIGNS SHALL BE INSTALLED IN ACCORDANCE WITH THE MTO TRAFFIC CONTROL MANUAL BOOK 7
- LOCATIONS OF EXISTING UTILITIES ARE NOT GUARANTEED. UNDERGROUND UTILITIES SHALL BE VERIFIED IN THE FIELD BY THE CONTRACTOR PRIOR TO THE COMMENCEMENT OF CONSTRUCTION. THE CONTRACTOR IS RESPONSIBLE FOR THE PRESERVATION OF ALL EXISTING INFRASTRUCTURE/ FACILITIES AS WELL AS NOTIFYING ALL UTILITY COMPANIES PRIOR TO COMMENCING WORK AND COORDINATE CONSTRUCTION ACCORDINGLY.
- W. ALL ON-SITE MATERIAL SHALL BE PROPERLY STORED, SECURED, MONITORED AND COVERED AS REQUIRED. SPECIFICALLY, ALL PVC PIPE SHALL BE COVERED WHILE STORED ON-SITE.

PARKING LOT

GENERAL

- A. SUBGRADE MATERIAL SHALL BE COMPACTED TO A DRY DENSITY OF AT LEAST 98% OF THE MATERIAL'S SPMDD. SUBGRADE SHALL BE PROOF ROLLED AND CERTIFIED BY THE GEOTECHNICAL CONSULTANT PRIOR TO PLACEMENT OF
- GRANULAR 'B'. B. GRANULAR 'A' AND 'B' SHALL BE COMPACTED TO A DRY DENSITY OF 100% OF
- THE MATERIAL'S RESPECTIVE SPMDD. ASPHALT SHALL BE COMPACTED TO A MINIMUM OF 97% OF THE MARSHALL
- BULK DENSITY. JOINTS WITH EXISTING ASPHALT SHALL BE SAW CUT STRAIGHT PRIOR TO PLACING NEW ASPHALT. WHERE EXISTING ASPHALT IS THICKER THAN 75 mm, A 500 mm WIDE BY 40 mm DEEP LAP JOINT SHALL BE GROUND INTO EXISTING ASPHALT PRIOR TO THE PLACEMENT OF SURFACE COURSE ASPHALT (SEE
- ALL GRANULAR AND ASPHALT MATERIAL SHALL BE PLACED IN ACCORDANCE WITH OPSS.MUNI 310 AND OPSS.MUNI 314.
- TACK COAT SHALL BE APPLIED AT THE DIRECTION OF THE ENGINEER PRIOR TO THE PLACEMENT OF SURFACE COURSE ASPHALT.
- CONCRETE CURB SHALL BE IN ACCORDANCE WITH OPSD 600.110 AND OPSS.MUNI 353. SUBDRAIN TO BE INSTALLED PER OPSD 216.021. CURB DEPRESSIONS AT SIDEWALK CROSSINGS SHALL BE IN ACCORDANCE WITH OPSD
- H. CONCRETE CURB TERMINATIONS SHALL BE CONSTRUCTED IN ACCORDANCE WITH OPSD 608.010. CONCRETE SIDEWALK SHALL BE IN ACCORDANCE WITH OPSD 310.010 AND OPSS
- 351. SUBBASE TO CONSIST OF 150 mm DEPTH GRANULAR 'A'. SIDEWALK RAMPS TO BE CONSTRUCTED IN ACCORDANCE WITH OPSD 310.033 AND TACTILE WALKING SURFACE INDICATORS WHERE SPECIFIED IN ACCORDANCE WITH OPSD
- J. ENTRANCE TO BE CONSTRUCTED IN ACCORDANCE WITH OPSD 350.010.

STORM SEWER

- A. STORM MAINTENANCE HOLES AND CATCH BASIN MAINTENANCE HOLES SHALL BE IN ACCORDANCE WITH OPSD 701.010, 701.011, 701.012, 701.013, 701.014, AND
- B. MAINTENANCE HOLES SHALL BE BENCHED IN ACCORDANCE WITH OPSD 701.021. MINIMUM BENCHING WIDTH SHALL BE 300 mm. CATCH BASIN MAINTENANCE HOLES SHALL HAVE A SUMP PER OPSD 701.010.
- MAINTENANCE HOLE AND CATCH BASIN MAINTENANCE HOLE STEPS SHALL BE IN ACCORDANCE WITH OPSD 405.010.
- D. MAINTENANCE HOLE FRAMES AND GRATES SHALL BE IN ACCORDANCE WITH OPSD 401.010, TYPE 'A' OPEN COVER.
- CATCH BASINS AND DOUBLE CATCH BASINS SHALL BE IN ACCORDANCE WITH OPSD 705.010 AND 705.020 C/W 600 mm SUMP. CATCH BASINS AND DOUBLE CATCH BASINS FRAMES AND GRATES SHALL BE IN
- ACCORDANCE WITH OPSD 400.020. CATCH BASIN LEADS - 250 mm WITH MINIMUM 0.7% SLOPE. DOUBLE CATCH
- BASIN LEADS 300 mm MINIMUM 0.7% SLOPE. FROST STRAPS SHALL BE INSTALLED ON ALL MAINTENANCE HOLES IN
- ACCORDANCE WITH OPSD 701.100 WITH 'QUICK ANCHORED' BOLTS. DROP STRUCTURES AT MAINTENANCE HOLES SHALL BE PROVIDED IN ACCORDANCE WITH OPSD 1003.010.

SANITARY SEWERS

- SANITARY MAINTENANCE HOLES SHALL BE IN ACCORDANCE WITH OPSD 701.010. SANITARY MAINTENANCE HOLES SHALL BE BENCHED IN ACCORDANCE WITH OPSD 701.021 ALL CONNECTIONS TO MAINTENANCE HOLES SHALL INCLUDE A KOR-N-SEAL RUBBER BOOT PIPE CONNECTION.
- FROST STRAPS SHALL BE INSTALLED ON ALL MAINTENANCE HOLES IN ACCORDANCE WITH OPSD 701.100 WITH 'QUICK ANCHORED' BOLTS.
- MAINTENANCE HOLE STEPS SHALL BE IN ACCORDANCE WITH OPSD 405.010 MAINTENANCE HOLE FRAME AND COVER SHALL BE IN ACCORDANCE WITH OPSD
- 401.010, TYPE 'A' CLOSED COVER. ALL PROPERTY BARS SHALL BE PRESERVED AND REPLACED BY AN OLS AT THE MAINTENANCE HOLE STRUCTURES EXCEEDING 5.0m IN DEPTH SHALL INCLUDE
 - SAFETY PLATFORM IN ACCORDANCE WITH OPSD 404.020. DROP STRUCTURES AT MAINTENANCE HOLES SHALL BE PROVIDED IN ACCORDANCE WITH OPSD 1003.020.
 - ANGLE OF CONNECTION BETWEEN THE SERVICE AND SEWER EXCEEDS 90°. SANITARY SEWER TESTING SHALL INCLUDE INFILTRATION, EXFILITRATION MANDREL, AND CCTV.

RADIUS BENDS SHALL BE USED ON ALL SEWER CONNECTIONS WHERE THE

- ALL MATERIALS SHALL SHALL BE CSA CERTIFIED.
- MINIMUM COVER OVER WATERMAIN, SERVICE LATERALS AND HYDRANT LEADS SHALL BE 1.7 m AT ALL POINTS. WHERE MINIMUM COVER CAN NOT BE ACHIEVED FROST PROTECTION WITH INSULATION SHALL BE PROVIDED PER

DETAIL (INSET) AND AS PER MANUFACTURERS SPECIFICATIONS.

- SEPARATION BETWEEN WATERMAINS AND SEWERS SHALL BE A MINIMUM OF 0.50 THRUST PROTECTION SHALL BE PROVIDED BY THE USE OF MECHANICAL JOINT
- FITTINGS AND RESTRAINERS. RESTRAINT SYSTEM TO BE INSTALLED IN ACCORDANCE WITH MANUFACTURER'S RECOMMENDATIONS. ALL WATERMAIN INSTALLED WITHIN ENGINEERED FILL SHALL BE RESTRAINED.
- ALL PVC WATERMAIN AND PE RESIDENTIAL SERVICES SHALL BE INSTALLED WITH 10 GAUGE, MULTI-STRAND TRACER WIRE BETWEEN HYDRANTS AND OTHER CONDUCTING APPURTENANCES. TRACER WIRE CONTINUITY MUST BE TESTED AND CERTIFIED BY THE CONTRACTOR. ALL CONNECTIONS SHALL BE MADE WITH
- "DRYCONN WATERPROOF CONNECTORS" OR APPROVED EQUIVALENT. CATHODIC PROTECTION (S-12 ZINC ANODES @ 30 m SPACING) SHALL BE

DISINFECTION OF THE WATERMAINS SHALL BE IN ACCORDANCE WITH THE LATEST

- PROVIDED IN ACCORDANCE WITH OPSS.MUNI 442. GENERAL INSTALLATION AND TESTING OF WATERMAIN SHALL BE IN ACCORDANCE WITH OPSS.MUNI 421, OPSS.MUNI 701 AND MUNICIPAL SPECIFICATIONS.
- REVISION OF AWWA C651 SPECIFICATIONS. OTHERWISE DIRECTED BY THE GEOTECHNICAL CONSULTANT) AND COMPACTED TO THE COMPLETE WATER SYSTEM, INCLUDING SERVICE CONNECTIONS TO THE PROPERTY LINE AND HYDRANTS SHALL BE TESTED IN ACCORDANCE WITH THE TOWN'S WATERMAIN TESTING PROTOCOL. CONNECTIONS TO EXISTING WATERMAINS SHALL NOT BE MADE UNTIL WRITTEN AUTHORIZATION IS PROVIDED BY THE
 - ENGINEER AND THE TOWN. TOWN STAFF SHALL CONDUCT BACTERIOLOGICAL SAMPLING ON NEWLY INSTALLED
 - FOLLOWING SATISFACTORY WATER SAMPLING, CONTRACTOR SHALL TIE-IN WATER SERVICES AT THE DISCRETION OF MUNICIPAL STAFF.

- ALL MATERIALS SHALL BE CSA CERTIFIED AND IN ACCORDANCE WITH OPSS AND WITH THE TOWN DEVELOPMENT STANDARDS. B. STORM SEWER - PVC SDR 35 OR CONCRETE ES OR CLASS III. ALL SEWER TO BE JOINED WITH A GASKETED BALL AND SPIGOT SYSTEM. REINFORCED CONCRETE PIPE 450 mm DIAMETER OR GREATER FOR SEWER.
- SANITARY SEWER PVC SDR 35 WITH RUBBER GASKET JOINTS, MINIMUM 200 mm DIAMETER. SANITARY SERVICES - PVC SDR 28
- ALL WATERMAIN MATERIALS SHALL BE IN ACCORDANCE WITH NSF60 AND NSF61. WATERMAIN - C900 CLASS 150/DR 18 RATED PVC WITH RUBBER GASKET JOINT FITTINGS.
- PIPE RESTRAINERS SIGMA C-900. LIVE TAP SADDLES TO BE EPOXY COATED COMPLETE WITH STAINLESS STEEL
- MECHANICAL JOINT DUCTILE FITTINGS TO AWWA/ANSI C153/A21.53 INCLUDING PROTECTO-CAPS, CATALOGUE NO. 175P190 OR ÁPPROVED EQUIVALENT. ISOLATION VALVES TO BE RESILIENT SEAT GATE VALVES WITH MECHANICAL JOINTS, OPEN LEFT, CLOW OR MUELLER. VALVE BOXES TO BE 5-SL-48 SLIDING OR MUELLER MVB COMPOSITE COMPLETE WITH GUIDE PLATE AND DUCTILE
- ADJUSTABLE TOP AND LID OR APPROVED EQUAL. CAPS TO BE PAINTED BLUE. ALL SPECIFIED AGGREGATES SHALL BE IN ACCORDANCE WITH OPSS.MUNI1010. FILTER FABRIC - TERRAFIX 270R OR APPROVED EQUIVALENT. PERFORATED SUBDRAINS - 150 mm BIG 'O' WITH GEOTEXTILE FILTER SOCK OR
- APPROVED EQUIVALENT. AREA DRAINS TO BE NYOPLAST 8" DRAIN BASIN WITH DUCTILE IRON GRATE
- APPROVED OR EQUAL. P. RIGID INSULATION TO BE 50mm THICK HL-40 STYROFOAM

TOWN APPROVAL

10045 HIGHWAY 26 COMMERCIAL DEVELOPMENT TOWNSHIP OF COLLINGWOOD

DETAILS AND NOTES

DE-1

DESIGN: AO/KRL FILE: 122093 DRAWN: KRL DATE: FEB 2024 CHECK: AO SCALE: 1: 400

ENGINEER WITHOUT THE EXPRESS CONSENT OF TATHAM ENGINEERING LIMITED.

Drawing Name: 122093—DE—1.dwg, Plotted: Sep 06, 2024

BE REPORTED TO THE ENGINEER BEFORE

DISCLAIMER AND COPYRIGHT

CONTRACTOR MUST VERIFY ALL DIMENSIONS AND BE

COMMENCING WORK. DRAWINGS ARE NOT TO BE

RESPONSIBLE FOR SAME. ANY DISCREPANCIES MUST


TATHAM ENGINEERING LIMITED CLAIMS COPYRIGHT TO

THIS DRAWING WHICH MAY NOT BE USED FOR ANY

PURPOSE OTHER THAN THAT PROVIDED IN THE

CONTRACT BETWEEN THE OWNER/CLIENT AND THE

ENGINEER STAMP A. OVERHOLT

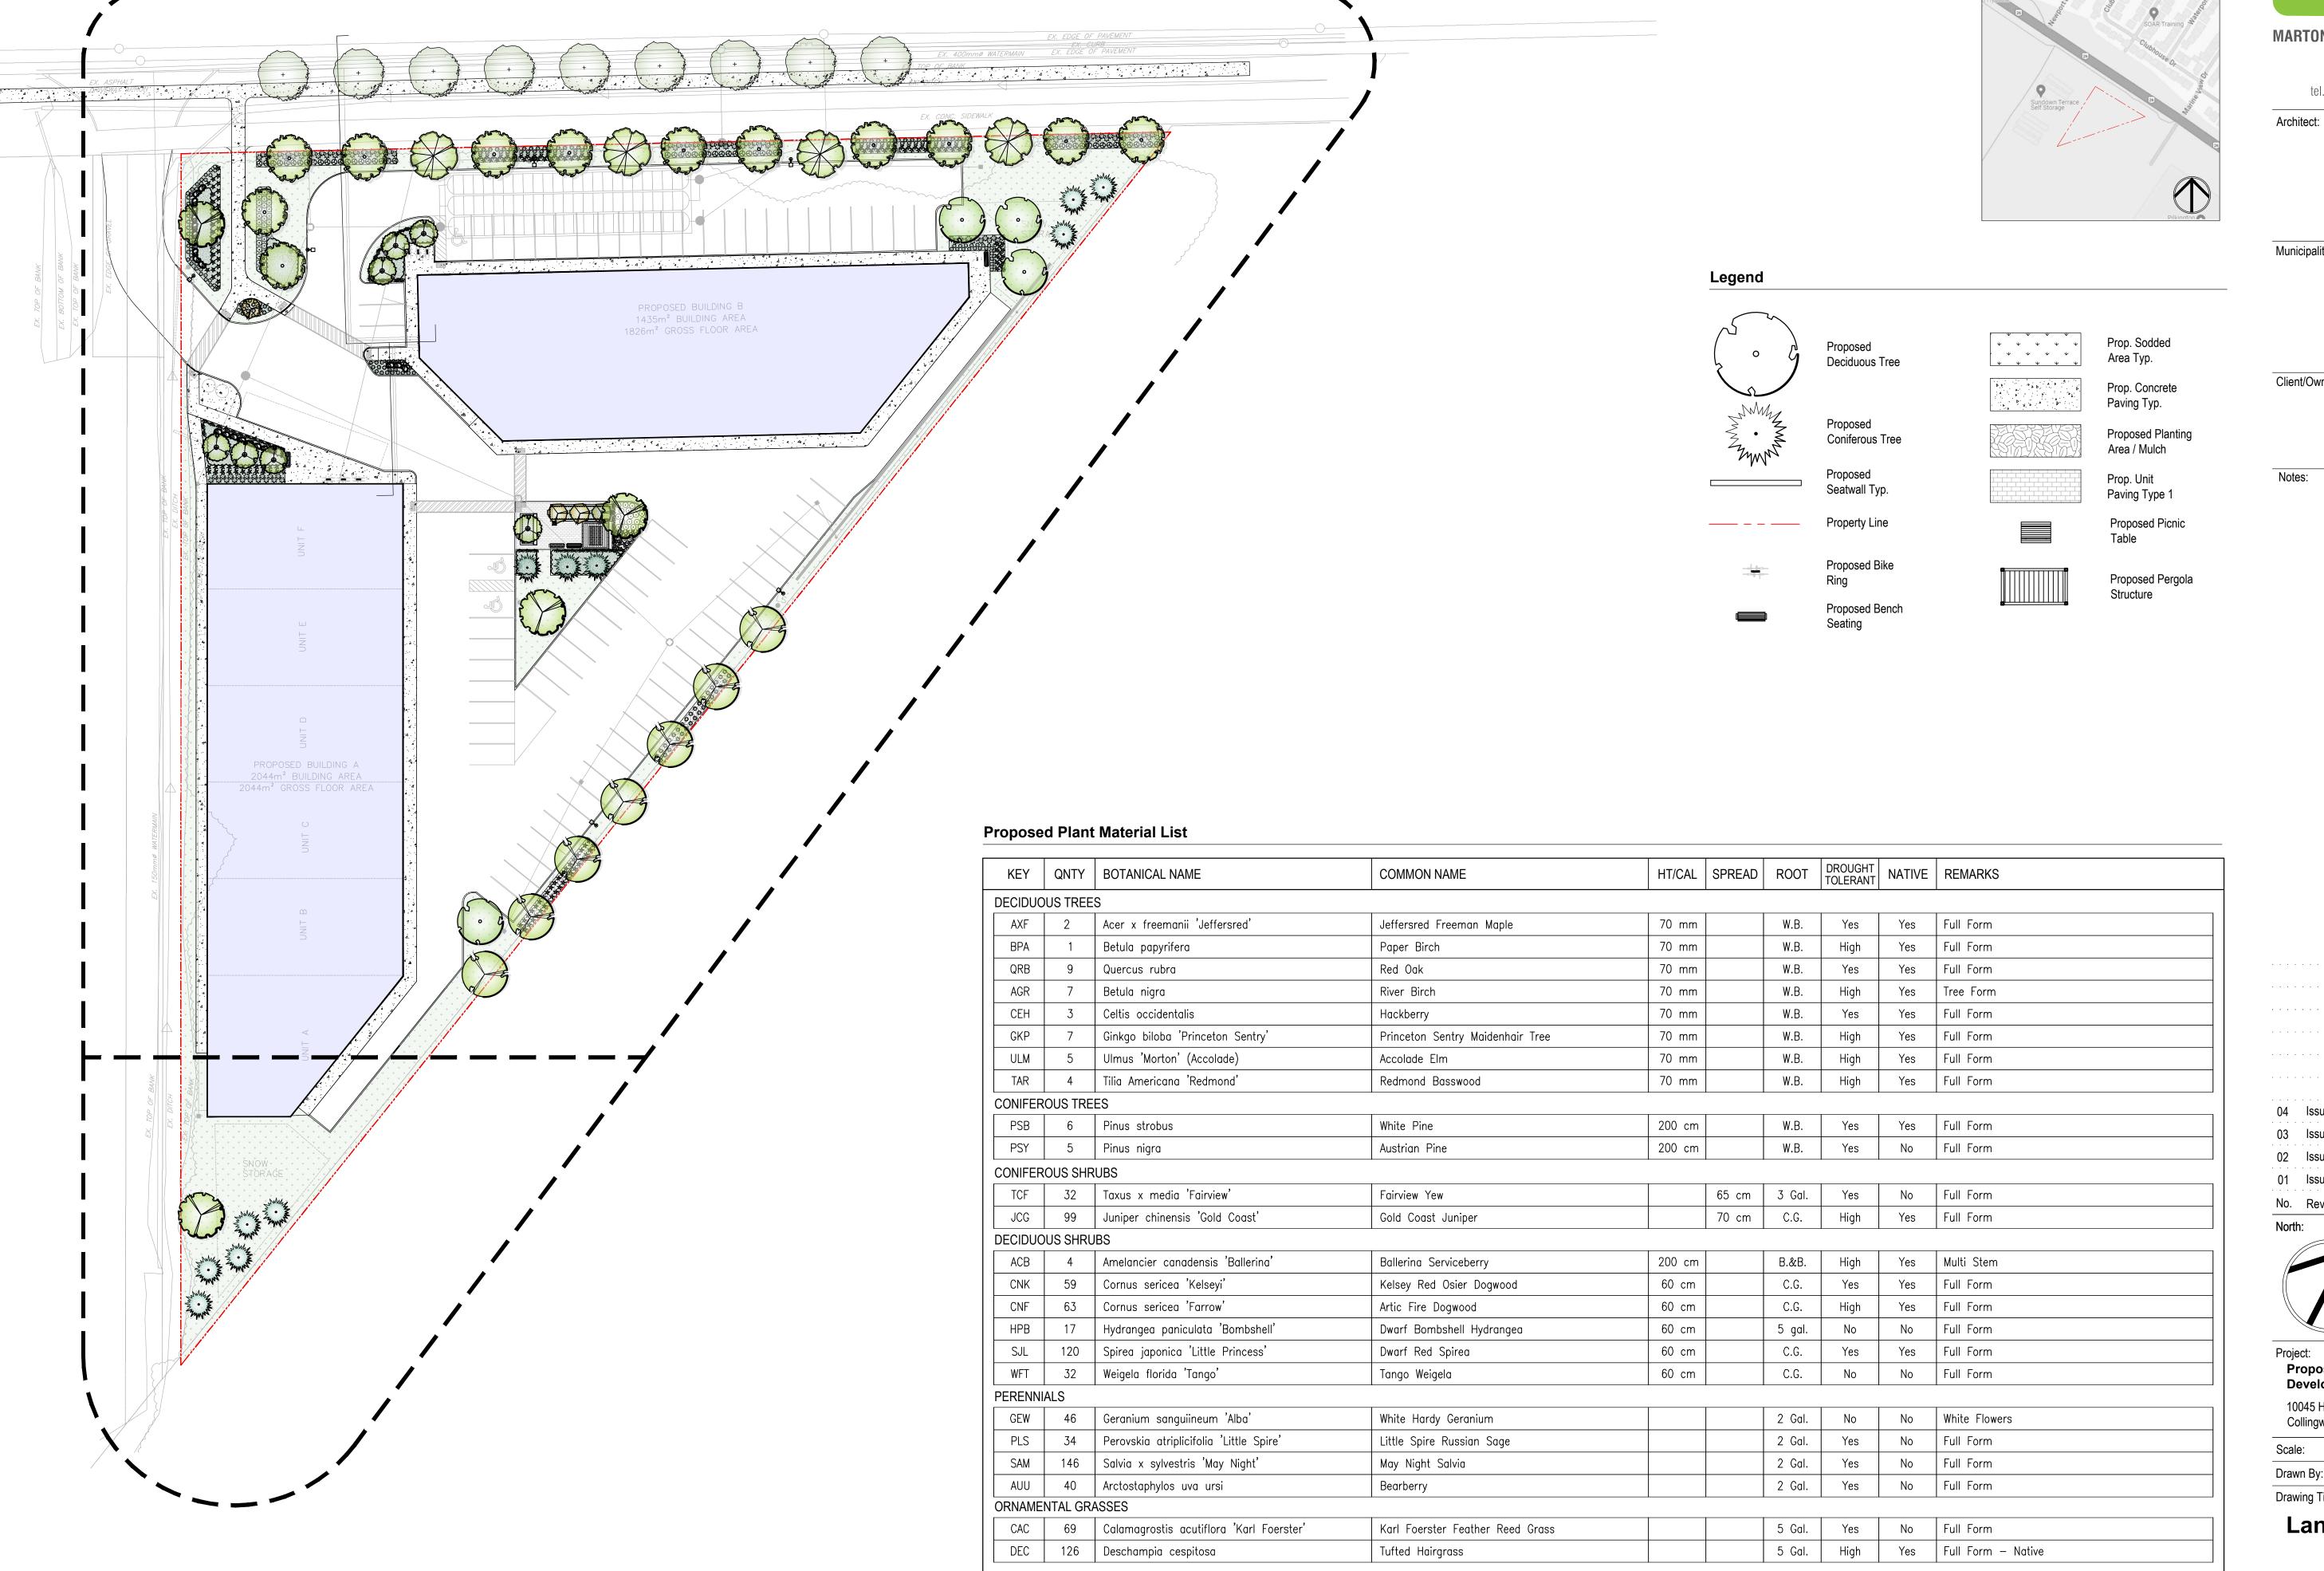



tel. 416.492.9966 | email. info@msla.ca

Municipality:



Client/Owner:

Notes:

04 Issued for Resubmission 03 Issued for Coordination 02 Issued for Submission 01 Issued for Coordination

No. Revision





09/04/24

08/15/24

03/21/24

02/12/24

Date

Proposed Residential Development


10045 Hwy 26 Collingwood, Ontario

1:400 Date: **Jun 2021 S.P.** Checked By: **L.M.** Drawn By:


Drawing Title:

Landscape Plan

Project No. Sheet No. 24103 L1-01

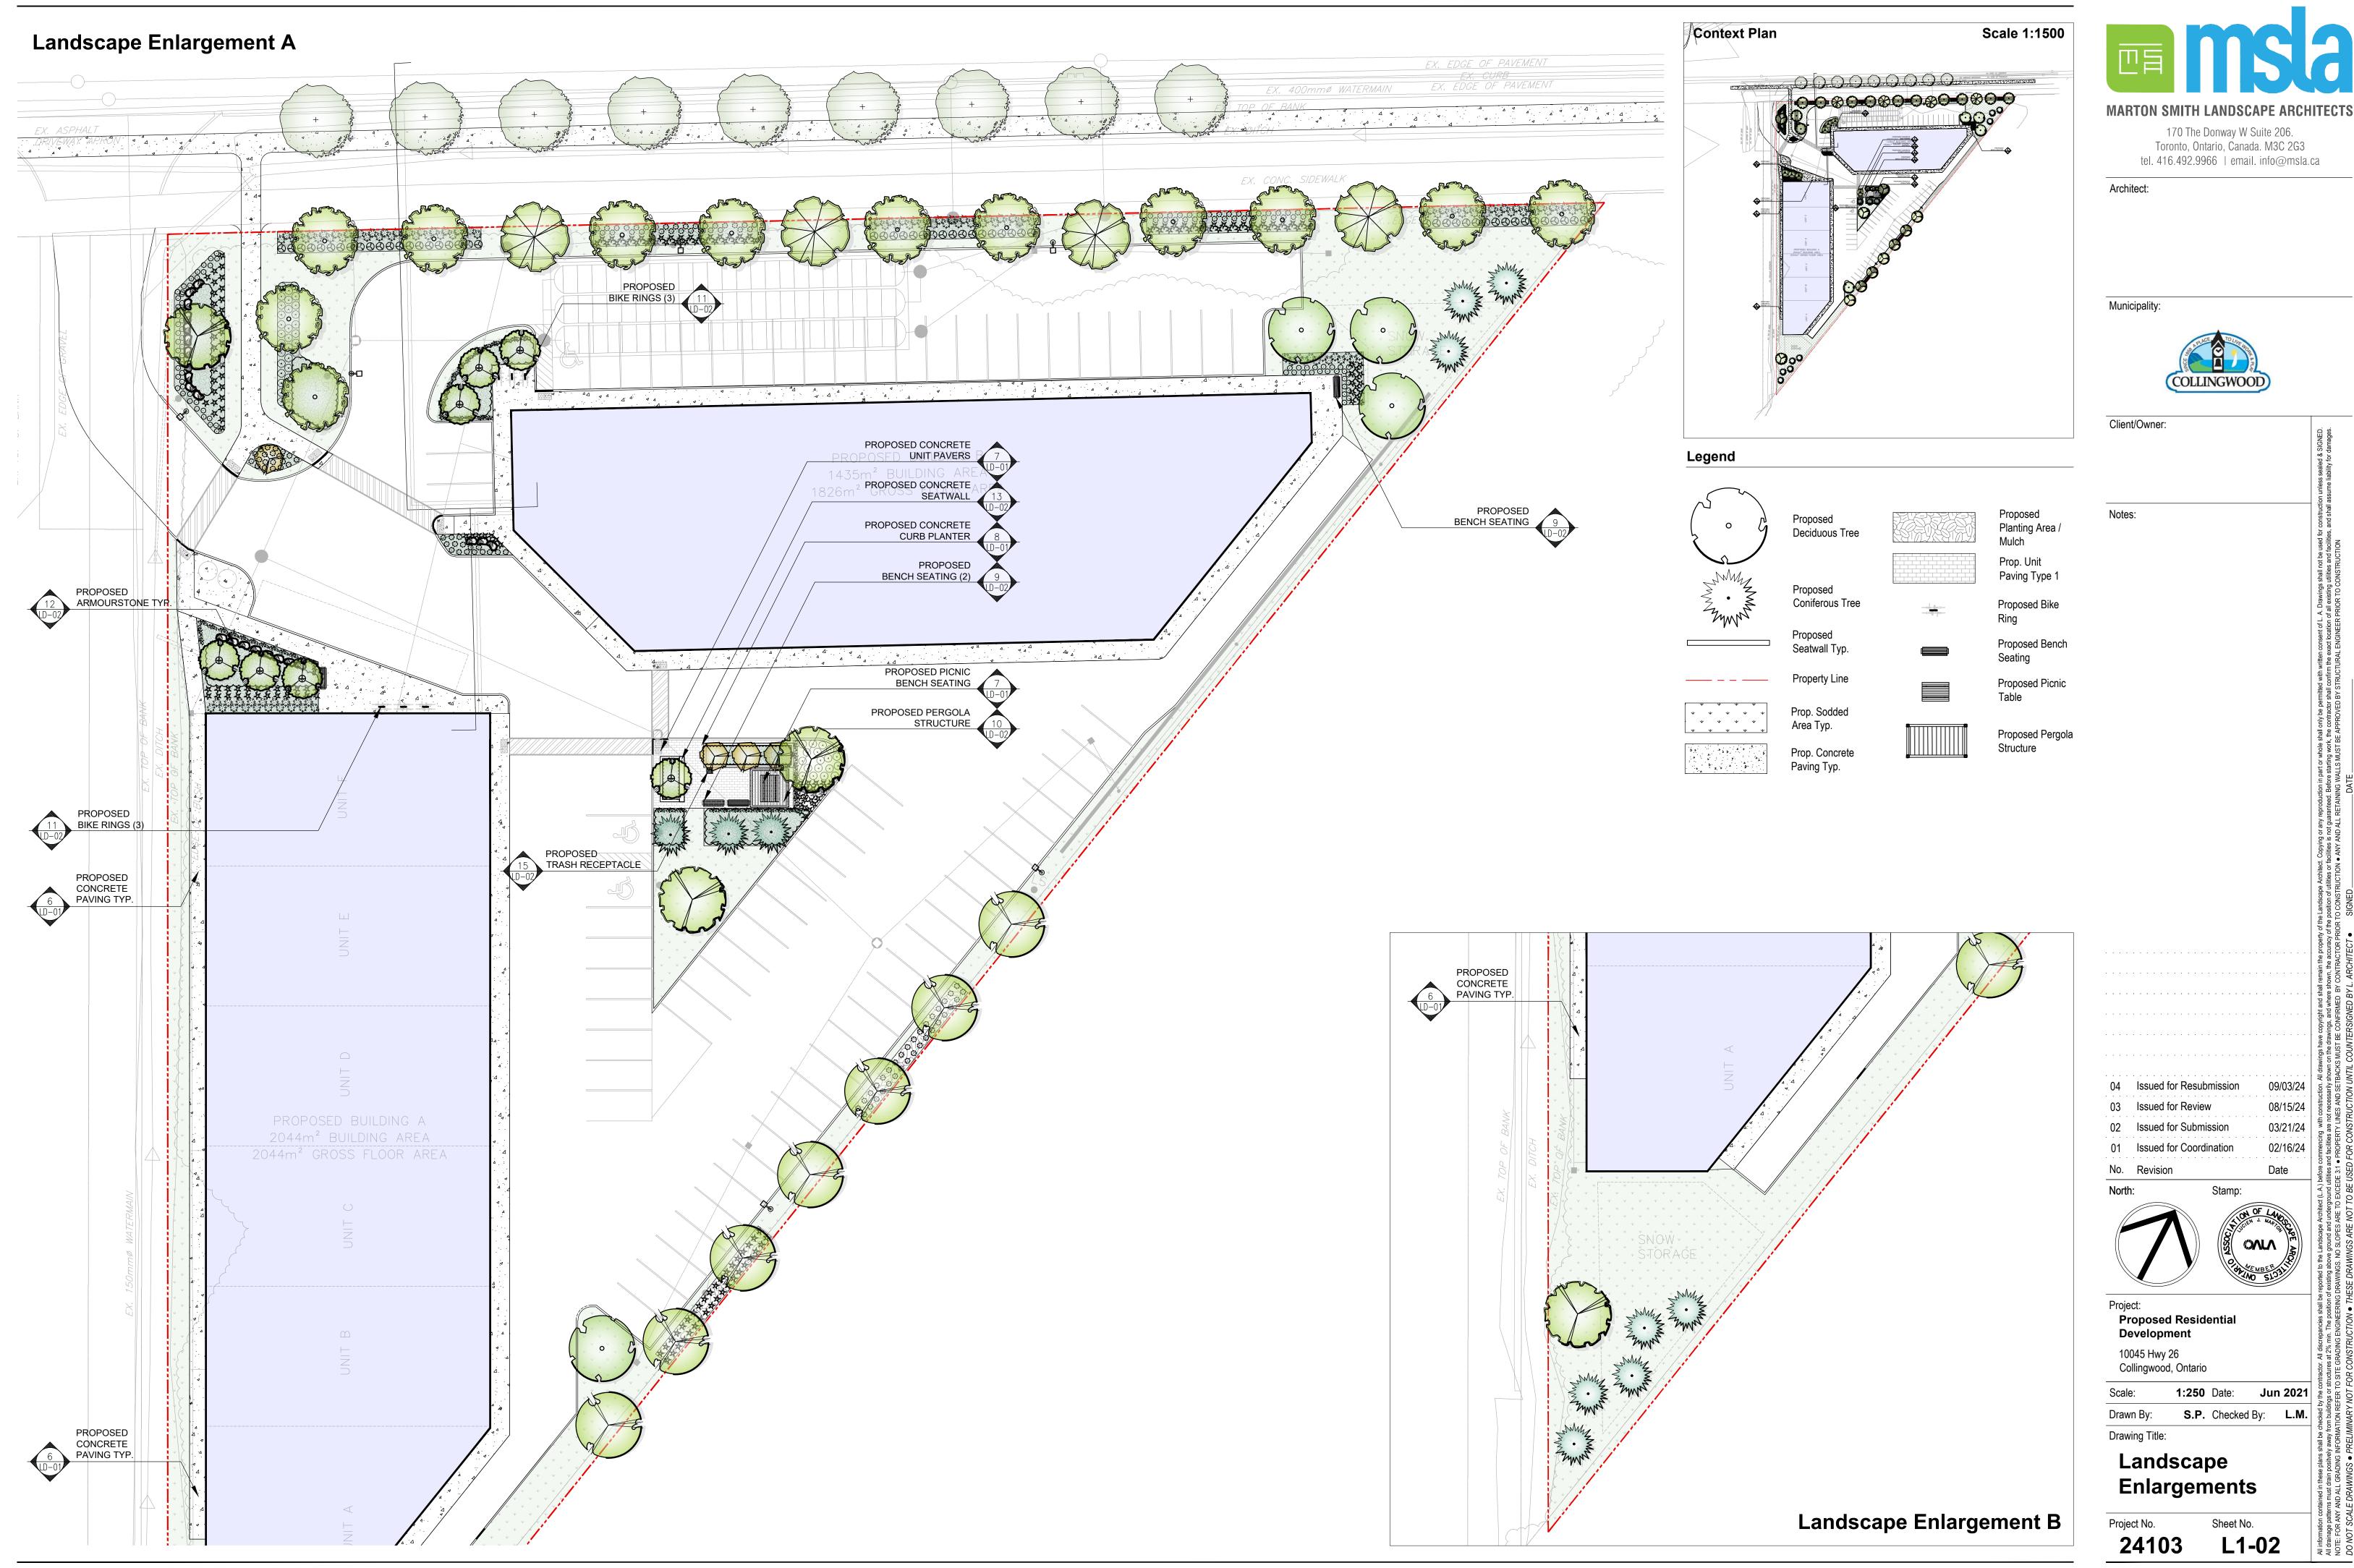



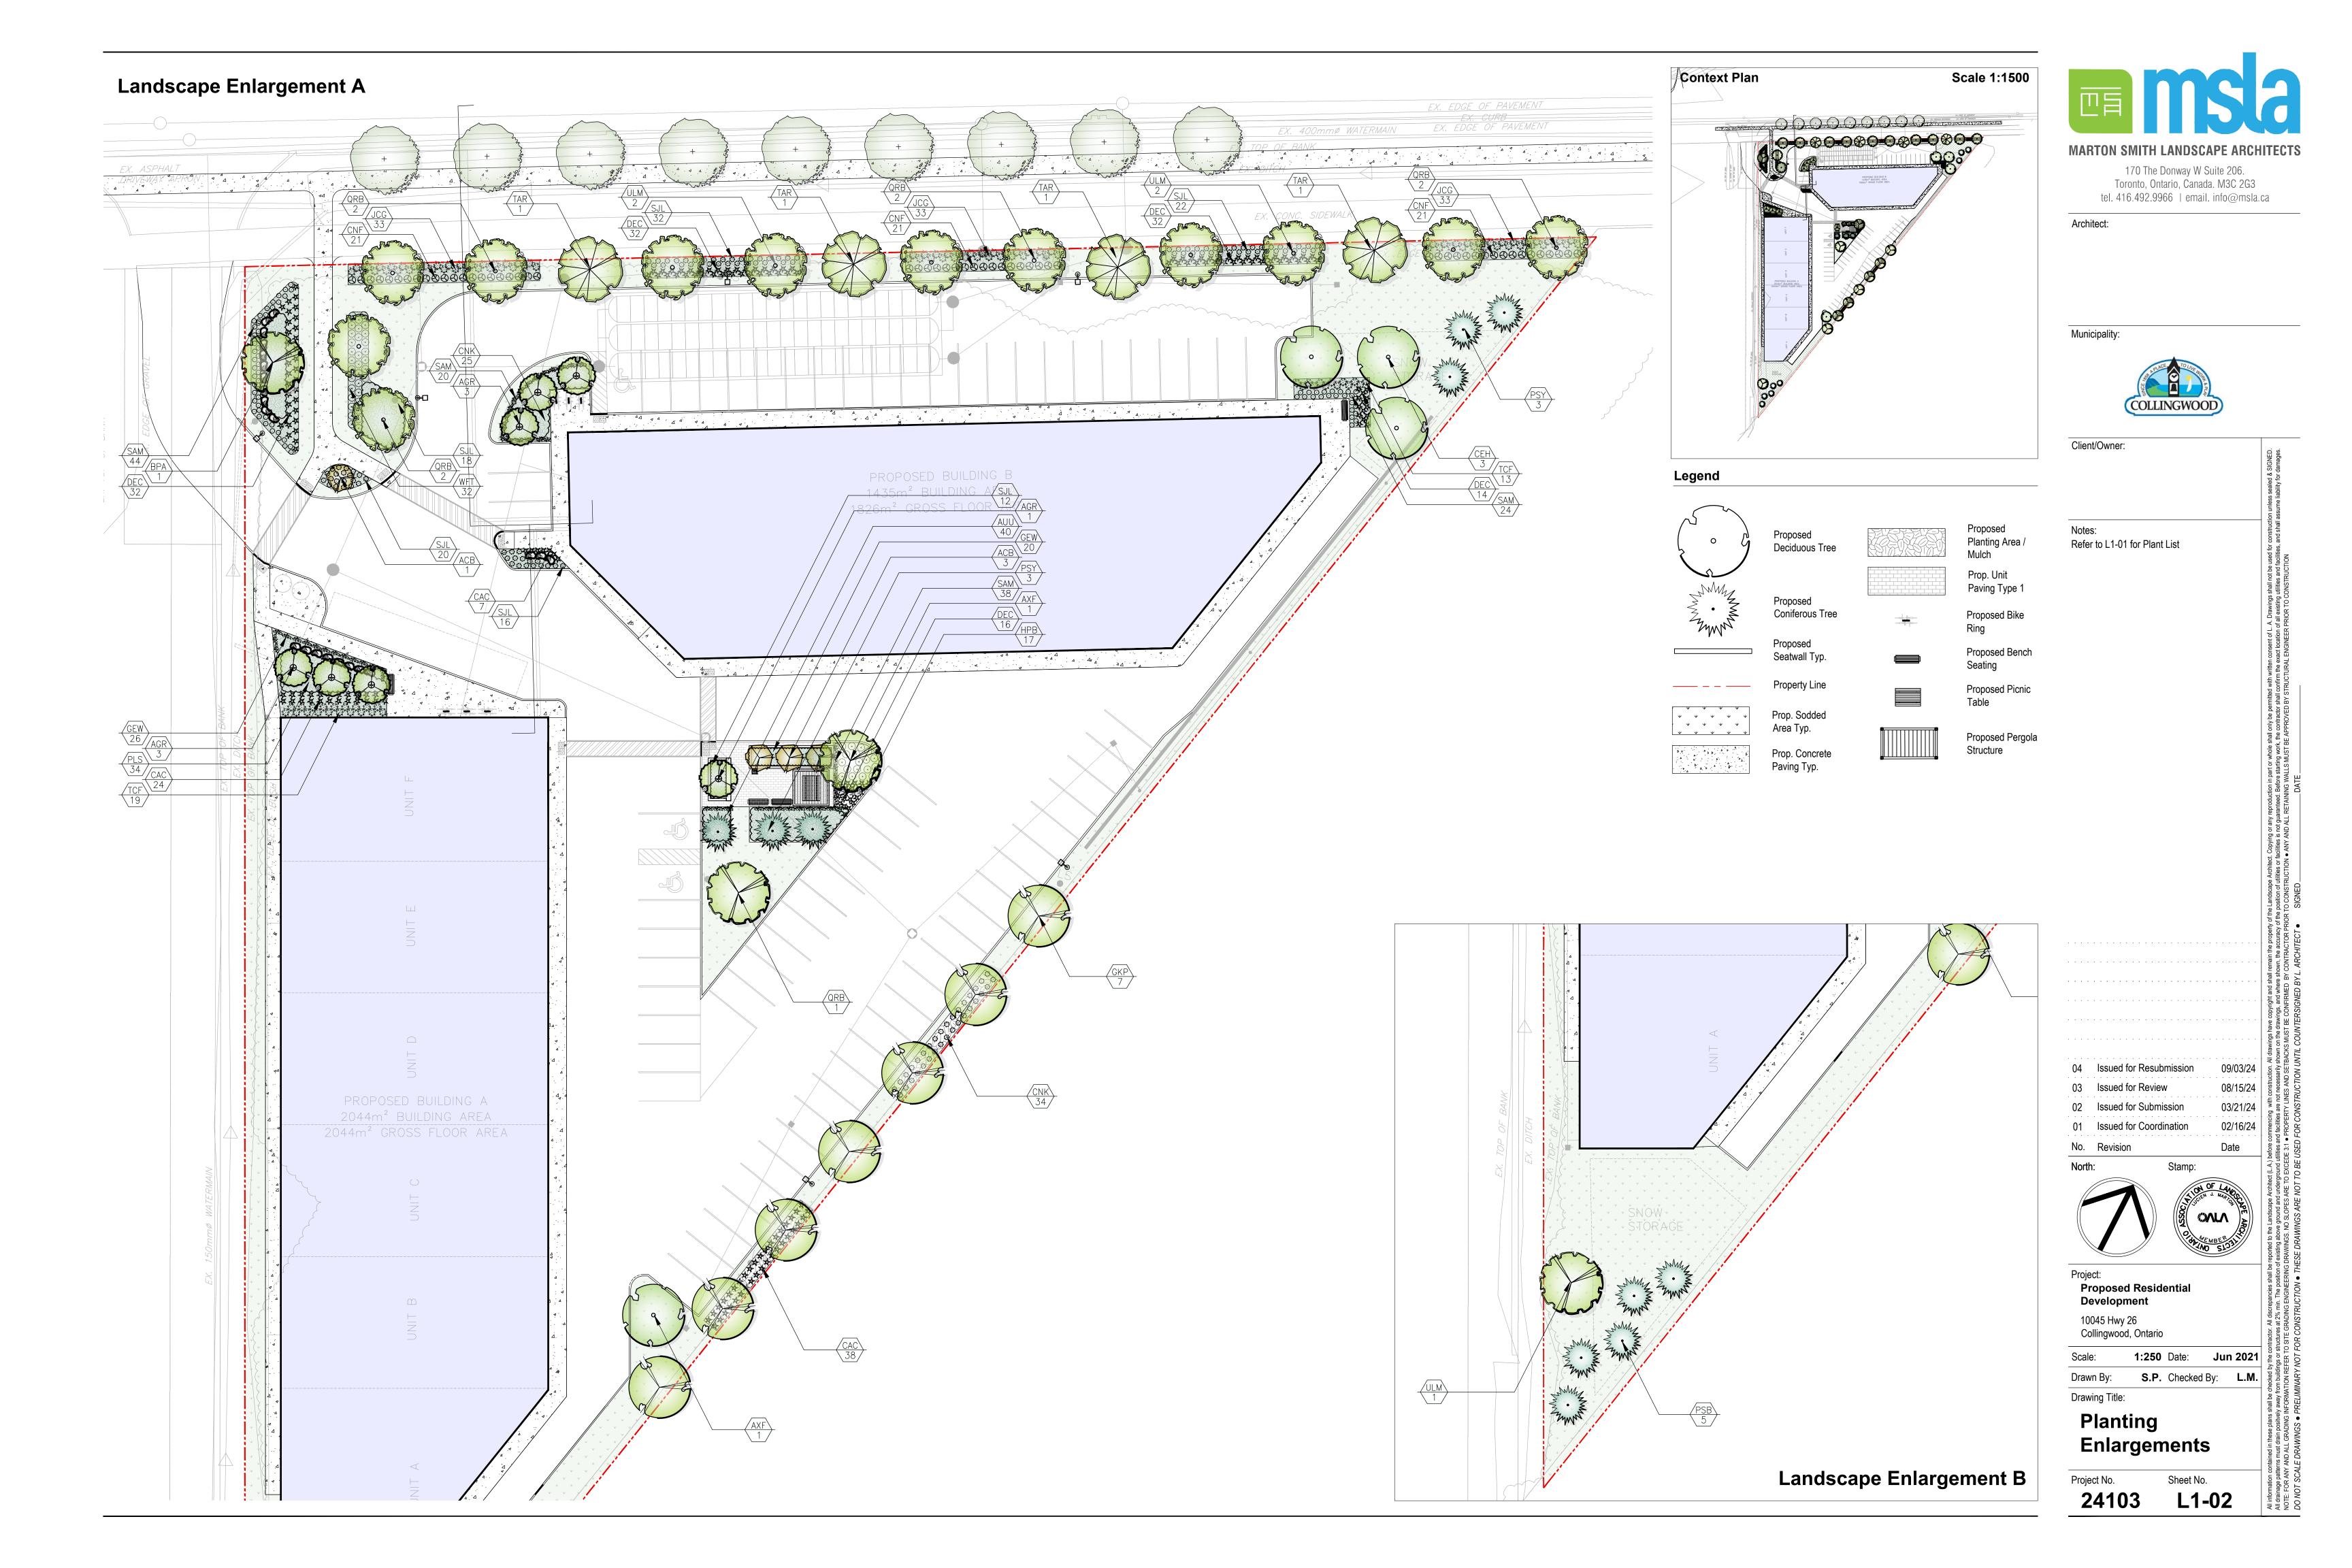

ROUGH GRADING

ROUGH GRADE AND FILL AREAS TO ESTABLISH SUBGRADE AS REQUIRED. PROVIDE DRAINAGE PATTERN AS INDICATED ON DRAWINGS.

ROUND SMOOTHLY ALL TOPS AND TOES OF SLOPES. COMPACT ALL AREAS TO 95% STANDARD PROCTOR DENSITY UNLESS SPECIFIED OTHERWISE. EXISTING TREES TO REMAIN ON SITE ARE TO BE PROTECTED AS DETAILED.

FINE GRADE ALL AREAS TO FINISHED GRADES AS SHOWN ON LAYOUT OR GRADING PLAN OR ARCHITECT'S SITE PLAN. PROVIDE UNIFORM SLOPES AWAY FROM THE BUILDING, UNLESS SPECIFIED OTHERWISE. SLOPES MAY NOT EXCEED 33 1/3% (3:1).

SPREADING OF TOPSOIL

SCARIFY THE SUBSOIL PRIOR TO THE SPREADING THE TOPSOIL. REMOVE ALL DEBRIS AND LEAVE A FINE-TEXTURED EVEN SURFACE. ALL TOPSOIL TO BE IMPORTED UNLESS PREVIOUSLY APPROVED BY LANDSCAPE ARCHITECT. OBTAIN APPROVAL FOR THE QUALITY OF ANY IMPORTED TOPSOIL BEFORE DELIVERY TO THE SITE. TOPSOIL IS TO BE COMPACTED TO CREATE A FIRM AND EVEN SURFACE.

USE NO. 1 GRADE TURFGRASS NURSERY SOD WHICH CONFORMS WITH THE SPECIFICATIONS OF THE NURSERY SOD GROWERS ASSOCIATION OF ONTARIO. ALL LAWN AREAS SHALL RECEIVE A MINIMUM OF 150MM (6") OF COMPACTED TOPSOIL, AND SHALL BE SODDED WITH #1 KENTUCKY BLUEGRASS - FESCUE. NO SOD SLOPES ARE TO EXCEED 3:1. SLOPE IN EXCESS OF 4:1 TO BE PEGGED.

MINERAL FERTILIZER

SOD TO MEET SPECIFICATIONS IN OPSS.802

APPLY THE FOLLOWING MINERAL FERTILIZER UNLESS SOILS TESTS SHOW OTHER REQUIREMENTS:

1. SODDED AREAS - 11% NITROGEN, 8% PHOSPHORUS AND 4% POTASH (11-8-4) AT THE RATE OF 4.5 KG OVER M2 (10 LBS OVER 1000 SQ.

2. PLANTING BEDS - 7% NITROGEN, 7% PHOSPHORUS AND 7% POTASH (7-7-7) AT THE RATE OF 40 GRAMS (4 OZ.) FOR EVERY BUSHEL OF TOPSOIL.

PREPARATION OF PLANTING BEDS

ALL PLANT BEDS TO BE CONTINUOUS. EXCAVATE ALL PLANTING BEDS TO THE DEPTH AS INDICATED ON THE DRAWINGS AND DETAILS, MIN 450mm(18"). BACKFILL ALL PLANTING BEDS WITH A SOIL MIXTURE CONSISTING OF SIX (6) PARTS OF SAND LOAM, ONE (1) PART OF FINELY PULVERIZED PEAT MOSS, TWO (2) PARTS OF WELL-ROTTED MANURE AND THE MINERAL FERTILIZER AS SPECIFIED ABOVE. ALSO ADD .58 KILOS BONEMEAL/CUBIC METER OF PLANTING SOIL (1 LB./CUBIC YARD). PREPARE THE PLANTING BEDS FOR PLANTING BEFORE

NOTE: IF THE EXISTING SOIL CONDITIONS ARE CLAY OR WET IN NATURE, CONTACT THE LANDSCAPE ARCHITECT FOR INSTRUCTIONS OF A SUITABLE SOIL MIXTURE. FAILURE TO DO THIS MAY RESULT IN DELAY OF APPROVAL AND ACCEPTANCE.

ALL PLANT MATERIAL SHALL CONFORM TO THE STANDARDS OF THE CANADIAN NURSERY TRADES ASSOCIATION FOR SIZE AND

THE DELIVERY OF THE PLANT MATERIAL TO THE JOB SITE. PLANTING BEDS TO MEET SPECIFICATIONS OF OPSS.803

ALL SHRUB AND TREE MATERIAL SHALL BE CONTAINER GROWN, POTTED, S/B OR B/B, UNLESS OTHERWISE NOTED. BARE ROOT PLANTING SHALL BE ACCEPTABLE FOR CERTAIN SPECIES DURING EARLY SPRING OR LATE FALL PLANTING SEASON. CONTRACTOR SHALL MAKE REQUESTS FOR ROOT CONDITION SUBSTITUTION IN WRITING TO THE LANDSCAPE ARCHITECT PRIOR TO COMMENCEMENT OF PLANTING OPERATIONS. ALL PLANT MATERIAL TO BE CLAY GROWN STOCK UNLESS OTHERWISE NOTED.

LANDSCAPE SPECIFICATIONS

SCALE: N.T.S. DATE:

PLANT MATERIALS

PLANT MATERIAL INSTALLATION

ALL TREES, SHRUBS AND GROUNDCOVERS SHALL BE PLANTED AS DETAILED & AS SHOWN ON THE PLANTING PLAN. ALL BEDS TO RECEIVE A COVER OF CLEAN MULCH TO A DEPTH OF 75mm(3"). FOR GUYING AND STAKING TREES, REFER TO PLANTING DETAILS. WRAP ALL DECIDUOUS TREES UNDER EXPERIENCED SUPERVISION ONLY TO THE SPECIFICATIONS OF THE ONTARIO LANDSCAPE CONTRACTORS ASSOCIATION.

PLANT MATERIAL SIZES AND CONDITIONS ARE TO BE AS INDICATED ON THE LANDSCAPE DRAWING.

THE INDIVIDUAL PLANT GROUPING TOTAL AS ILLUSTRATED ON THE PLANTING PLAN SUPERSEDES THE ESTIMATED QUANTITY ON THE MASTER PLANT LIST. CONTRACTOR MUST REPORT ANY DISCREPANCIES TO THE LANDSCAPE ARCHITECT IN WRITING BEFORE COMMENCING ANY WORK. CONTRACTOR WILL ASSUME FULL RESPONSIBILITY IF LANDSCAPE ARCHITECT IS NOT NOTIFIED OF DISCREPANCIES.

* MULCH - SHREDDED CEDAR BARK MULCH BY "GRO BARK" OR APPROVED EQUAL. LANDSCAPE ARCHITECT TO APPROVE MULCH

GENERAL MAINTENANCE

BEFORE INSTALLATION.

PROPER MAINTENANCE PROCEDURES ARE TO BE FULLY ADMINISTERED FOR ALL NEWLY CONSTRUCTED LANDSCAPE WORK, IN ACCORDANCE WITH LANDSCAPE ONTARIO SPECIFICATIONS (SECTION 1E - MAINTENANCE WORK). THIS SHALL APPLY ONLY DURING THE CONSTRUCTION PERIOD, UNLESS OTHERWISE SPECIFIED. CONTRACTOR IS RESPONSIBLE FOR MAINTENANCE OF SOD AND PLANTING UNTIL FINAL ACCEPTANCE BY LANDSCAPE ARCHITECT.

THE CONTRACTOR SHALL BE RESPONSIBLE FOR THE PROTECTION OF ALL TREES AND SHRUBS FOR WINTER PROTECTION AND FROM RODENT INJURY FOR THE DURATION OF GUARANTY PERIOD. PROTECTIVE GUARDS SHALL BE EMPLOYED AROUND ALL DECIDUOUS TREES. GUARDS TO BE 150MM DIA. PVC PIPE OR AS MUNICIPAL GUIDELINES. GUARDS SHALL BE INSTALLED PRIOR TO THE APPLICATION OF THE MULCH AND SHOULD BE PLACED A MINIMUM OF 50MM (2") OUT FROM THE TREE TRUNK ON ALL SIDES.

ALL SHRUBS AND CONIFEROUS TREES SHALL HAVE AN APPLICATION OF "SKOOT" OR APPROVED EQUIVALENT RODENT FORMULA, TO BE APPLIED AT THE END OF OCTOBER. FOLLOW MANUFACTURER'S DIRECTIONS FOR APPLICATION.

GENERAL REQUIREMENTS

USE ABOVE SPECIFICATIONS IN CONJUNCTION WITH THE GENERAL LANDSCAPE SPECIFICATIONS OF THE ONTARIO LANDSCAPE CONTRACTORS ASSOCIATION, THE NURSERY SOD GROWERS ASSOCIATION OF ONTARIO AND WITH THE GUIDE SPECIFICATIONS FOR NURSERY STOCK OF THE CANADIAN NURSERY TRADES ASSOCIATION. USE ONLY PLANT MATERIAL TRUE TO NAME, SIZE AND GRADE AS SPECIFIED ON PLANTING PLAN; PROVIDE SUFFICIENT LABELS OR MARKINGS TO INDICATE CLEARLY THE VARIETY, SIZE AND GRADE OF EACH SPECIMEN OR BUNDLE.


OBTAIN APPROVAL FOR SUBSTITUTIONS AS TO VARIETY, SIZE OR GRADE FROM THE LANDSCAPE ARCHITECT. USE ONLY NURSERY STOCK GROWN UNDER PROPER HORTICULTURAL PRACTICES, VIABLE, FREE FROM PEST AND DISEASE AND UNDAMAGED. CHECK LOCATIONS AND OBTAIN STAKEOUTS OF ALL UTILITY LINES BEFORE EXCAVATION. OBTAIN ALL NECESSARY PERMITS BEFORE COMMENCEMENT OF CONSTRUCTION. REPORT IN WRITING ANY DISCREPANCIES IN THE DRAWINGS, SPECIFICATIONS AND CONTRACT DOCUMENTS TO THE LANDSCAPE ARCHITECT BEFORE THE END OF THE BIDDING PROCESS AND COMMENCEMENT OF CONSTRUCTION. THESE SPECIFICATIONS MAY BE SUPERCEDED BY ADDITIONAL SPECIFICATIONS SET OUT IN THE TENDER DOCUMENTS. CONTRACTOR TO REVIEW ALL DOCUMENTS.

GUARANTEE PERIOD

SCALE: N.T.S. DATE:

PROVIDE ONE FULL YEAR GUARANTEE ON ALL LANDSCAPE WORK FROM DATE OF FINAL ACCEPTANCE BY LANDSCAPE ARCHITECT. GUARANTEE PERIOD MAY BE EXTENDED TO TWO FULL YEARS DEPENDING ON MUNICIPAL STANDARDS. CONTRACTOR TO VERIFY WITH OWNER AND LANDSCAPE ARCHITECT.


PLANT MATERIAL INSTALLATION

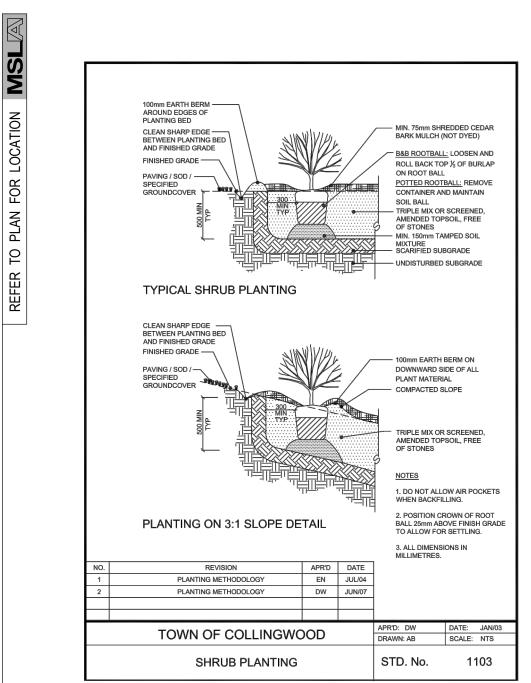

STANDARD SHRUB PLANTING DETAIL


SCALE: N.T.S. DATE:



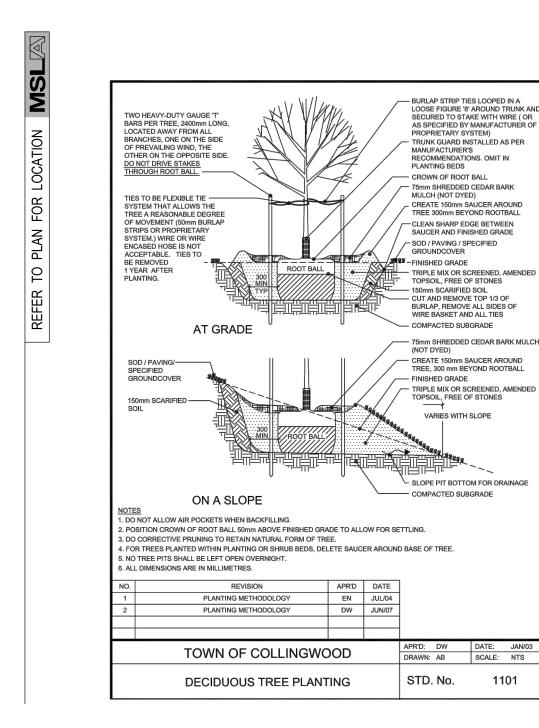

DECIDUOUS TREE PLANTING

 SCALE: N.T.S.




Face of building Concrete unit paving - refer to plan —— 25 x 300 rigid foam for type and pattern of paving. insulation - continuous 25 mm sharp clean sand along building wall compact to 95% S.P.D. 150 mm granular "A" - compact to 95% S.P.D. Expansion joints 2 to 4% minimum slope — -Refer to curb detail Thoroughly compacted subgrade SECTION ADJACENT BUILDING WITH CURB compact to 95% S.P.D. Concrete unit paving - refer to plan for type and pattern of paving. 25 mm sharp clean sand - compact to 95% S.P.D. - 150 mm granular "A" - compact to 95% S.P.D. NOTE REGARDING SAW CUTS: NO CUT PIECES SHOULD BE SMALLER THAN 40% OF THE ORIGINAL PAVER SIZE NOTE: USE "POLYMERIC JOINTING SAND" WITH ALL UNIT PAVER APPLICATIONS Pave edge by Pave Tech Inc. installed per manufacturer's specifications. Thoroughly compacted subgrade SECTION AT GRADE WITHOUT CURB compact to 95% S.P.D.

PRECAST CONCRETE PAVER INSTALLATION DETAIL

SCALE: N.T.S. SINGLE SOLDIER COURSE OPTION

5 LD-01


SCALE: N.T.S. DATE:

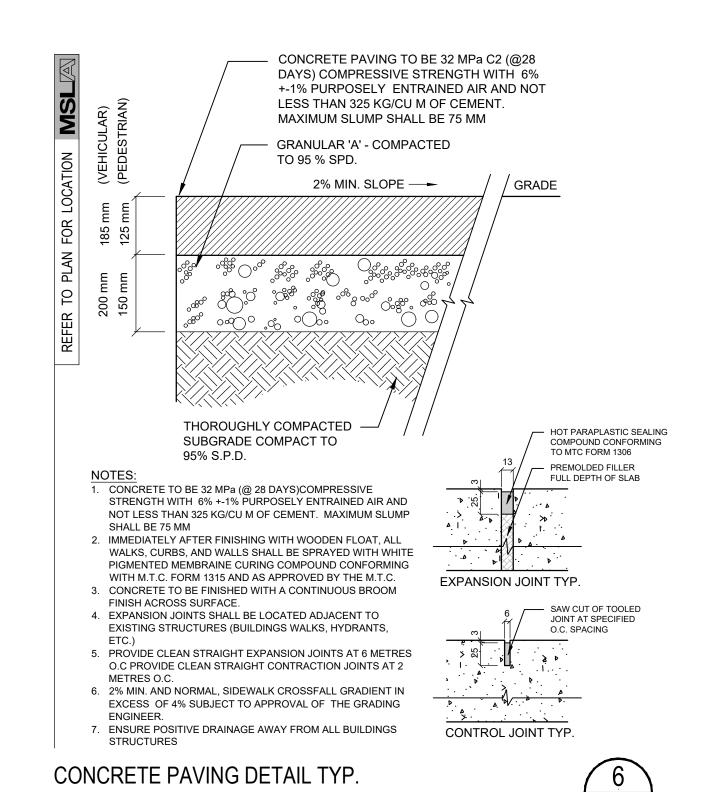





LD-01

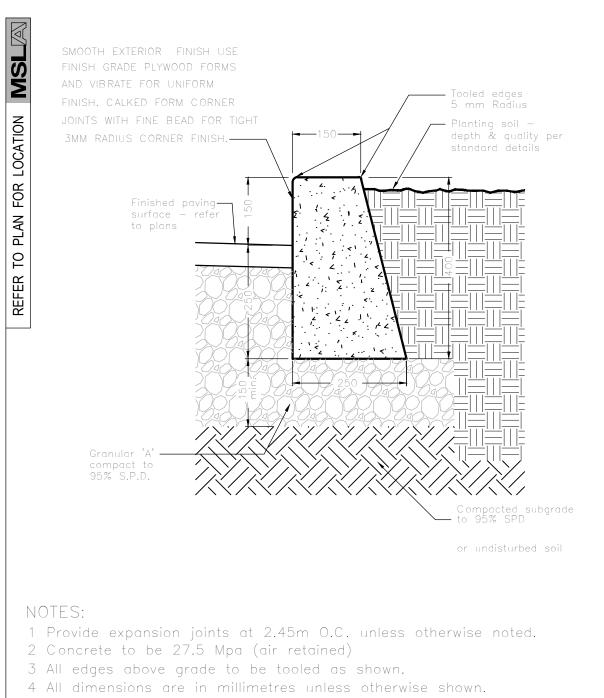

150mm HT CONC. CURB PLANTER DETAIL TYP.

SCALE: N.T.S. DATE:





Municipality:



Client/Owner:

Notes:

09/03/24 Issued for Resubmission 03 Issued for Review 08/15/24 02 Issued for Submission 03/21/24 02/12/24 01 Issued for Coordination No. Revision Date Proposed Residential Development 10045 Hwy 26 Collingwood, Ontario **1:400** Date: Jun 2021 Drawn By: **S.P.** Checked By: **L.M.** Drawing Title:


Sheet No.


LD-01


Landscape


Details

Project No.

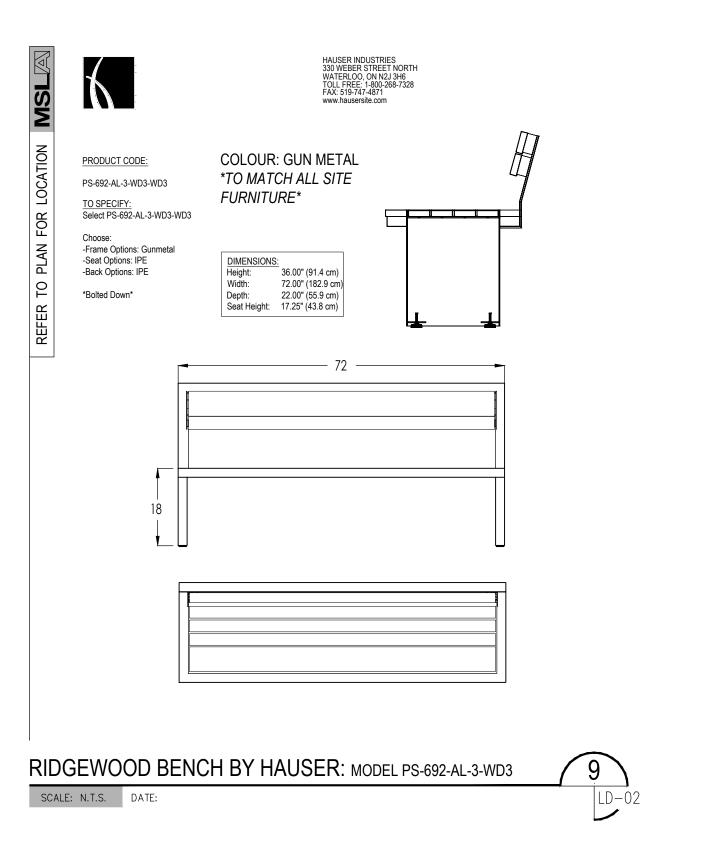

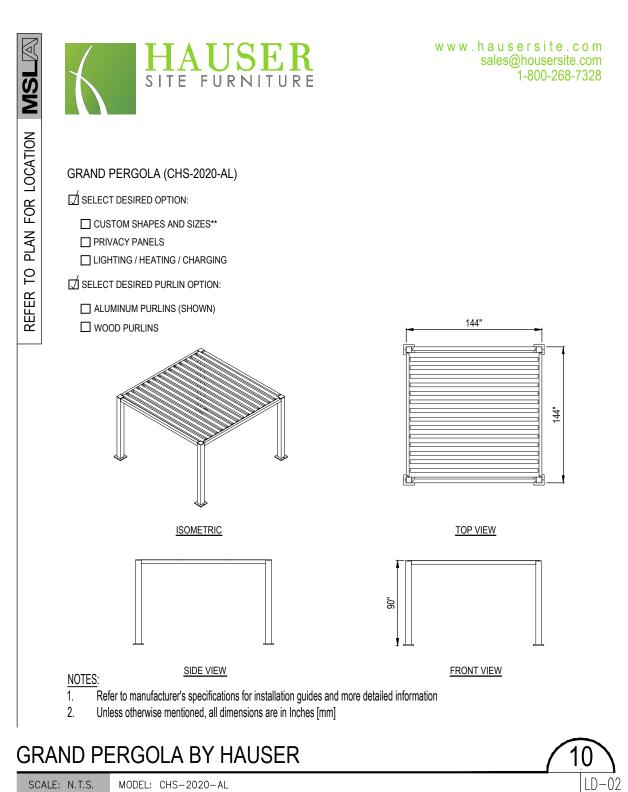


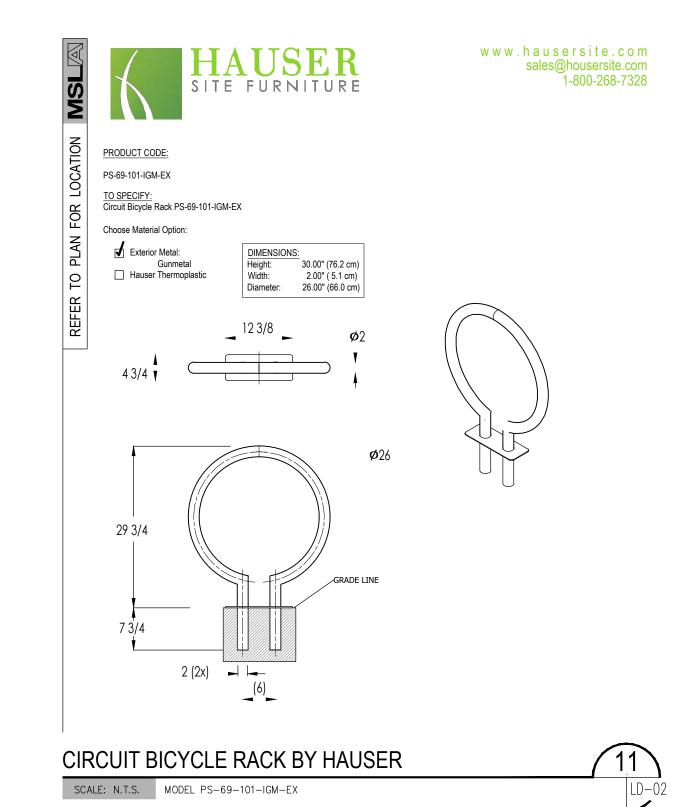


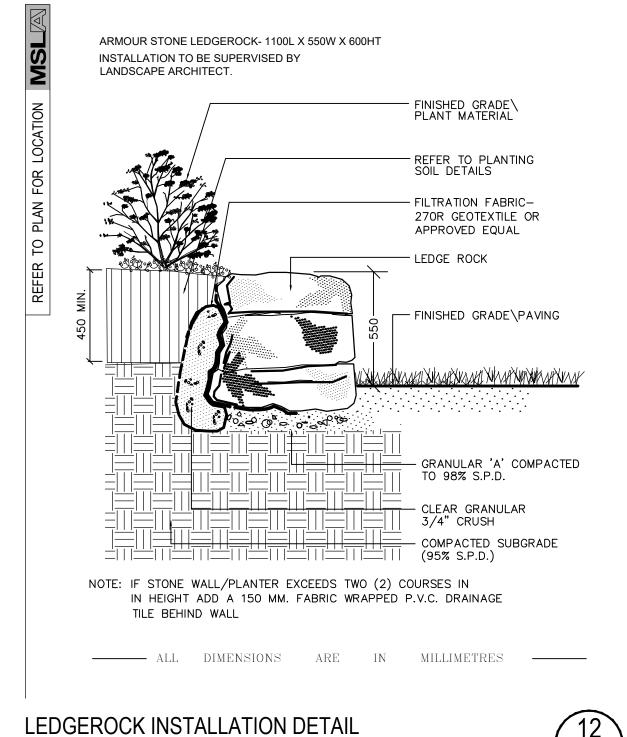

SCALE: N.T.S. DATE:



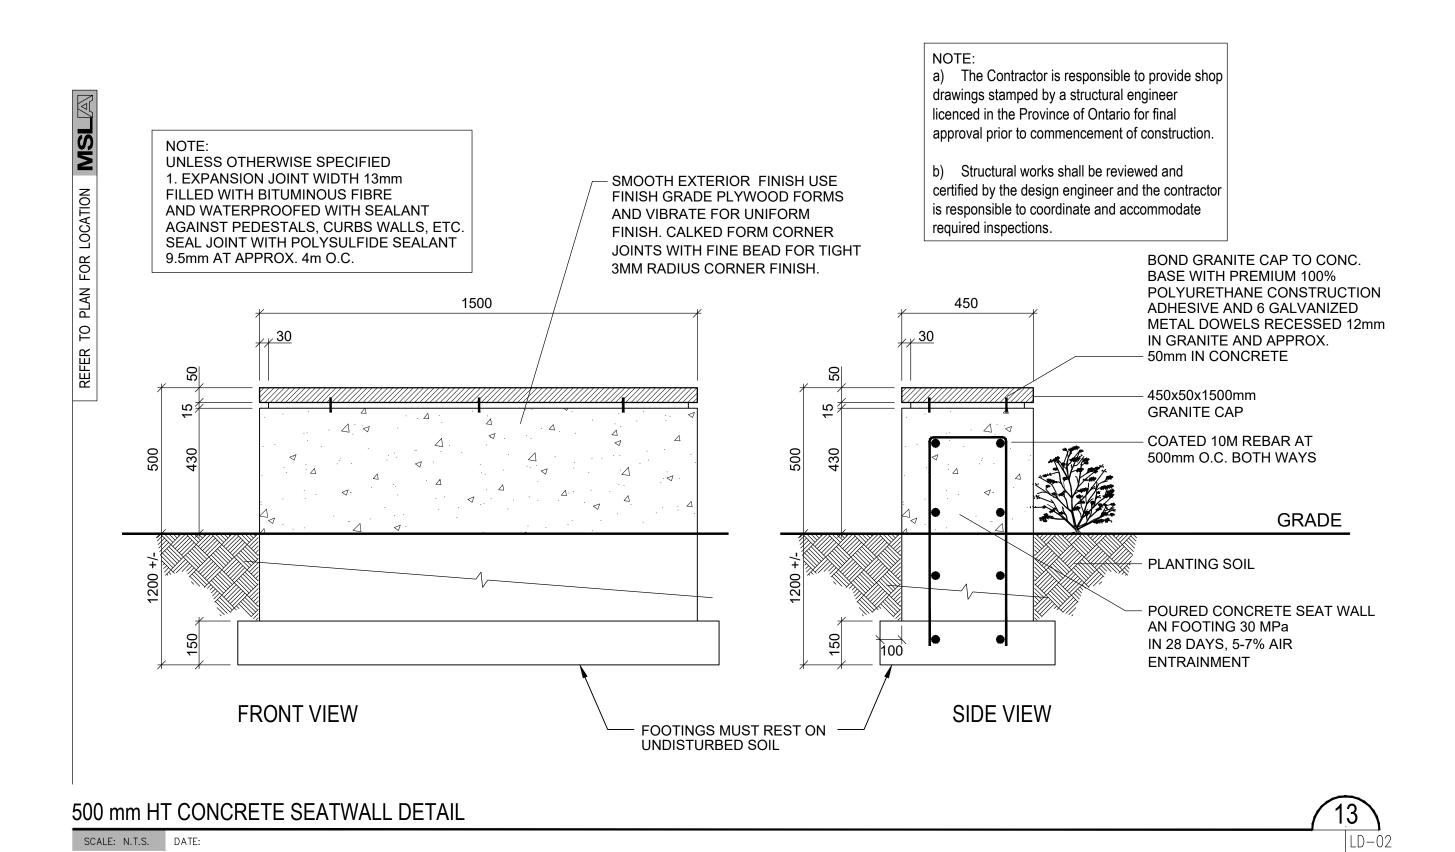

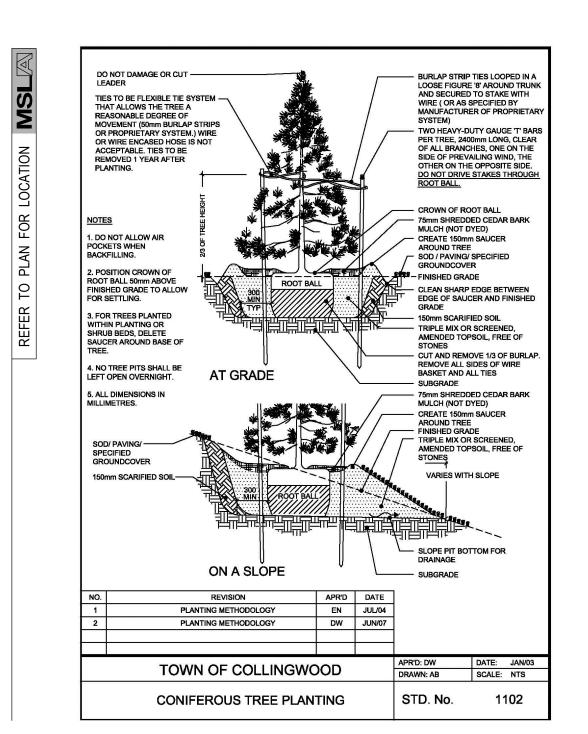


DECIDUOUS TREE PLANTING

SCALE: N.T.S.





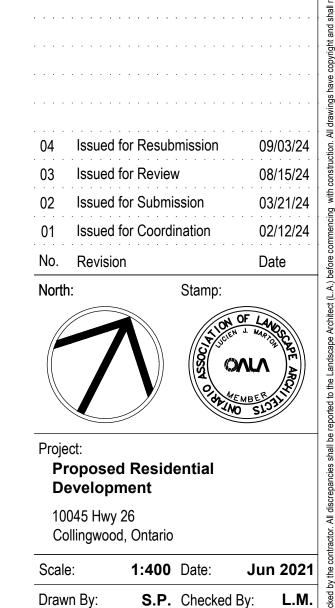


170 The Donway W Suite 206.


Toronto, Ontario, Canada. M3C 2G3

tel. 416.492.9966 | email. info@msla.ca

COLLINGWOOD

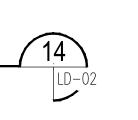


CONIC WASTE RECEPTACLE BY HAUSER

 

Drawing Title:

Landscape **Details**

Project No. Sheet No. **LD-02**

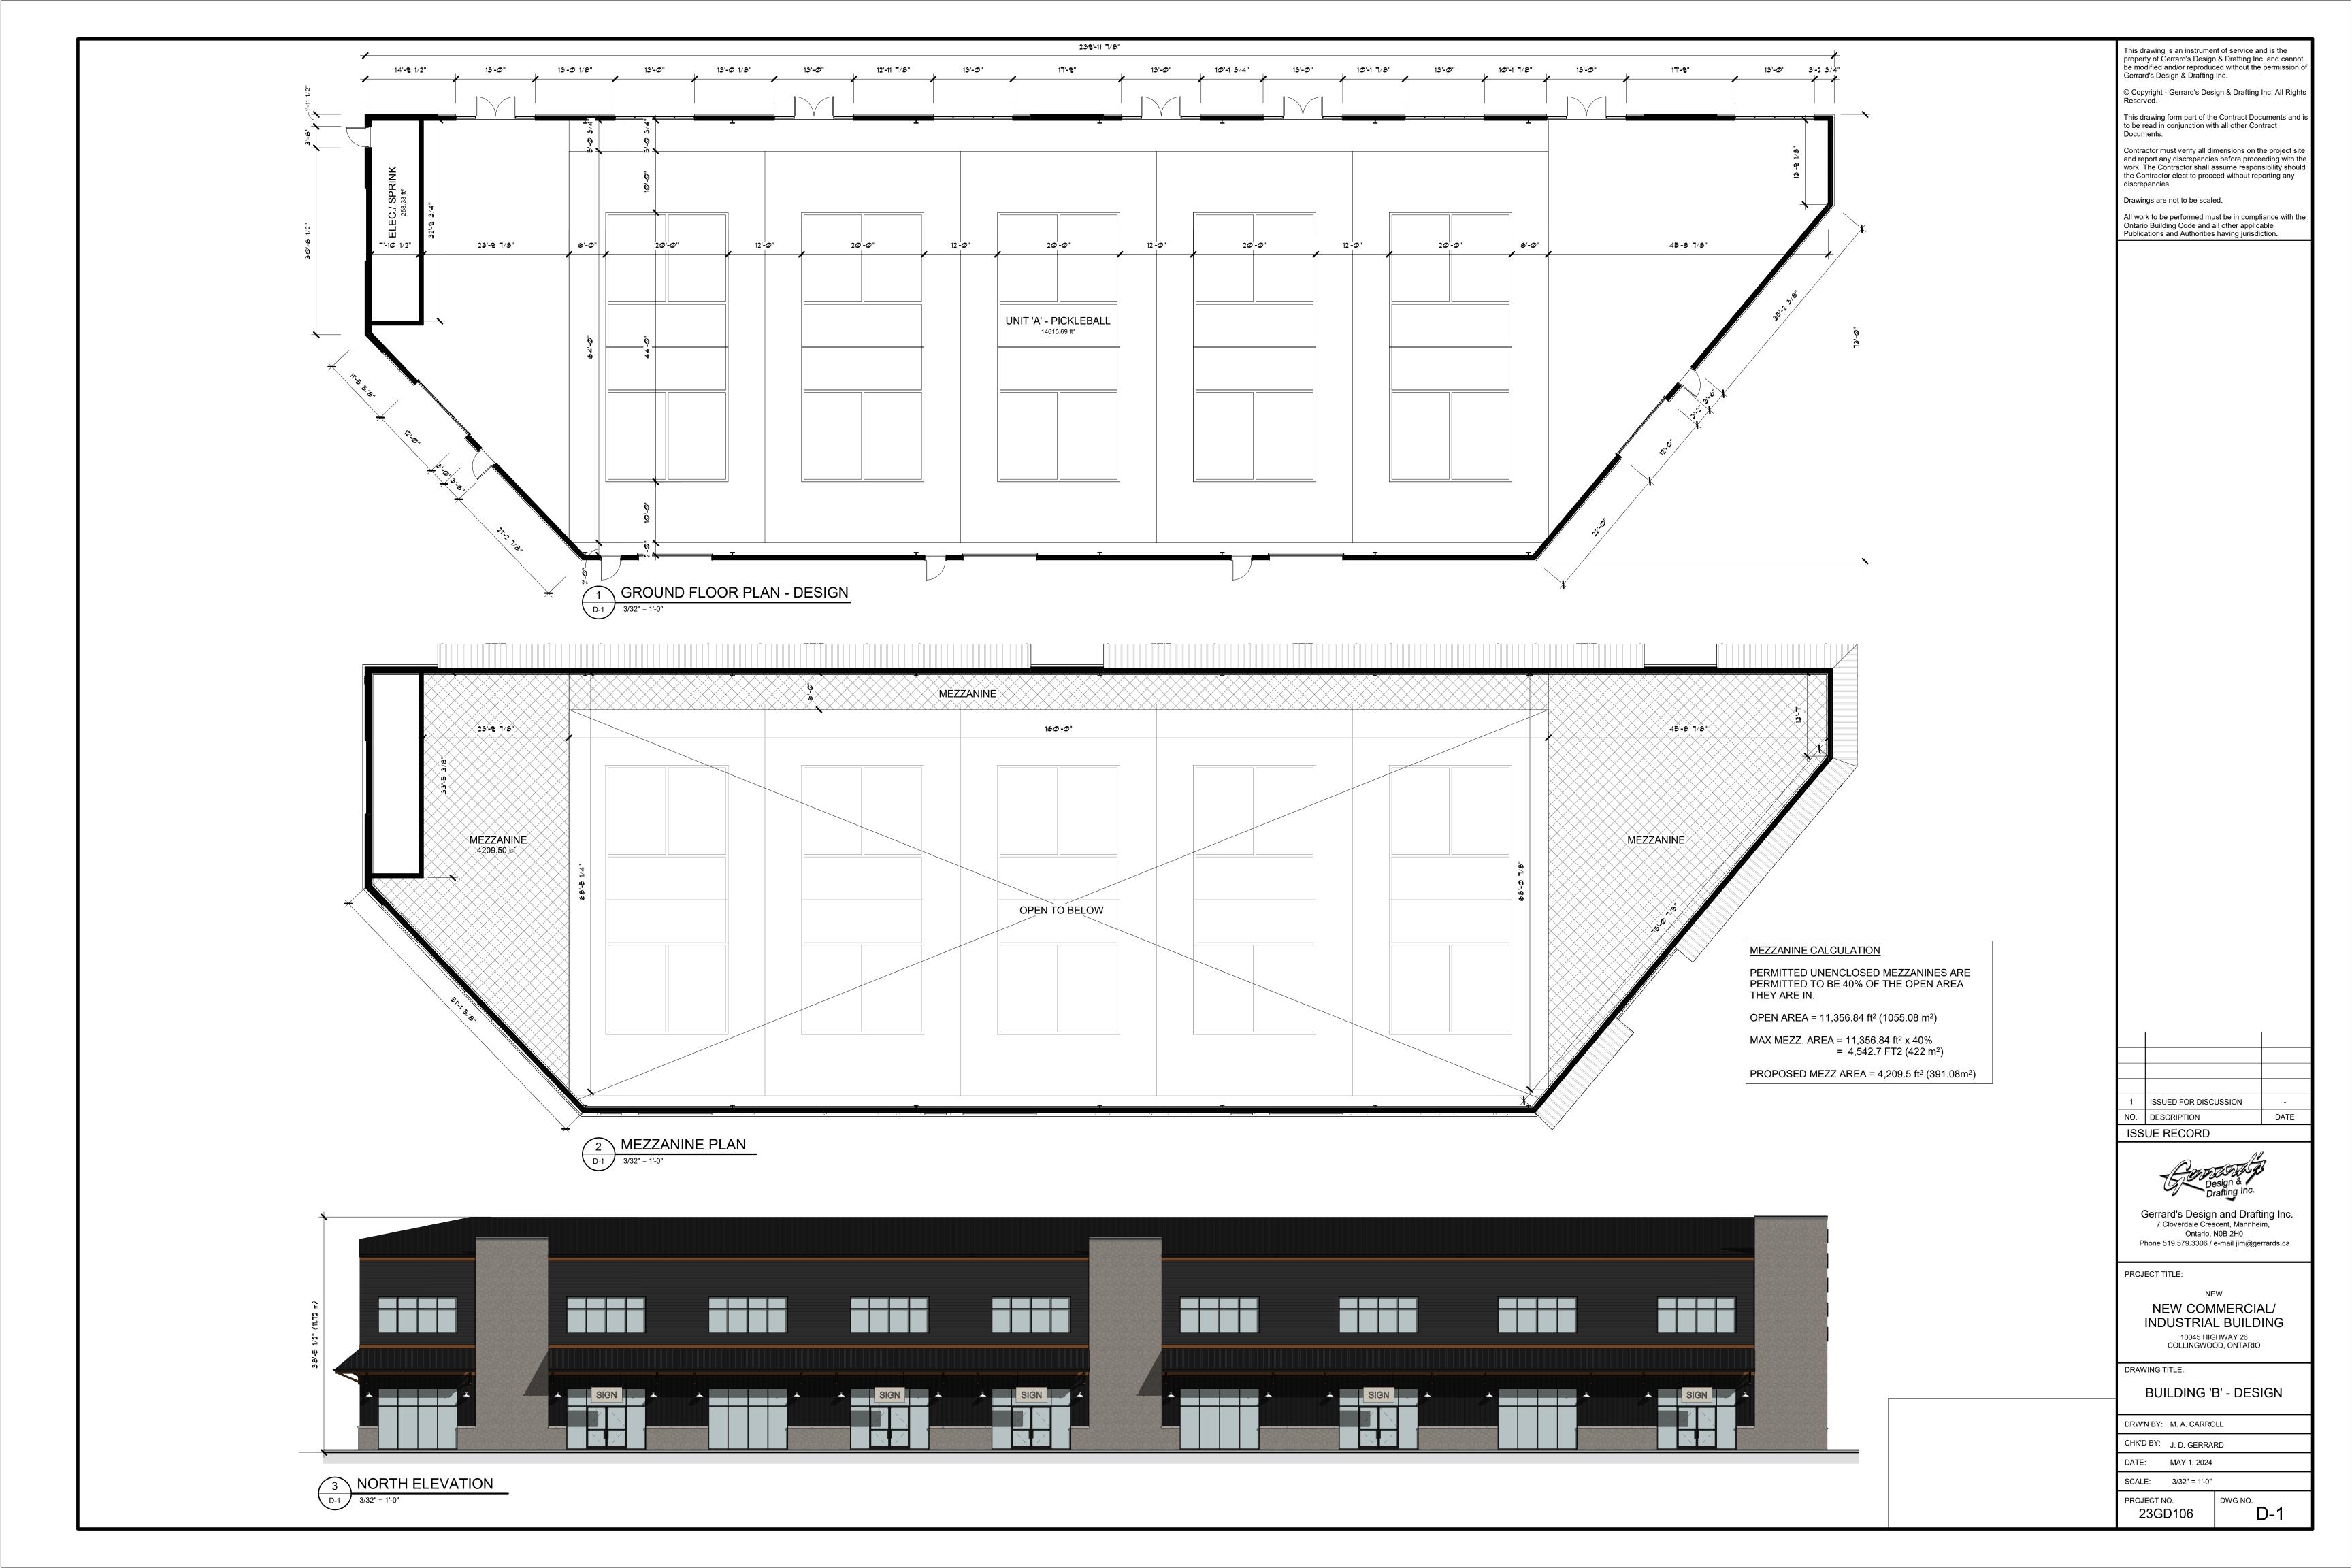



1 SOUTH ELEVATION
3/32" = 1'-0"



3 WEST ELEVATION
D-2 3/32" = 1'-0"







5 EAST ELEVATION
3/32" = 1'-0"





6 SOUTH ISOMETRIC

Gerrard's Design and Drafting Inc.
7 Cloverdale Crescent, Mannheim,
Ontario, N0B 2H0
Phone 519.579.3306 / e-mail jim@gerrards.ca

ISSUED FOR DISCUSSION

DATE

NO. DESCRIPTION

ISSUE RECORD

This drawing is an instrument of service and is the property of Gerrard's Design & Drafting Inc. and cannot be modified and/or reproduced without the permission of Gerrard's Design & Drafting Inc.

© Copyright - Gerrard's Design & Drafting Inc. All Rights

This drawing form part of the Contract Documents and is to be read in conjunction with all other Contract

Contractor must verify all dimensions on the project site and report any discrepancies before proceeding with the work. The Contractor shall assume responsibility should the Contractor elect to proceed without reporting any

All work to be performed must be in compliance with the

Ontario Building Code and all other applicable Publications and Authorities having jurisdiction.

Documents.

discrepancies.

Drawings are not to be scaled.

PROJECT TITLE:

NEW COMMERCIAL/ INDUSTRIAL BUILDING

10045 HIGHWAY 26 COLLINGWOOD, ONTARIO

DRAWING TITLE:

BUILDING 'B' - DESIGN

DRW'N BY: M. A. CARROLL

CHK'D BY: J. D. GERRARD

DATE: MAY 1, 2024

SCALE: 3/32" = 1'-0"

PROJECT NO. DV

23GD106

DWG NO.



2 WEST ELEVATION

D-3 3/32" = 1'-0"



3 EAST ELEVATION
D-3 3/32" = 1'-0"

This drawing is an instrument of service and is the property of Gerrard's Design & Drafting Inc. and cannot be modified and/or reproduced without the permission of Gerrard's Design & Drafting Inc.

© Copyright - Gerrard's Design & Drafting Inc. All Rights Reserved.

This drawing form part of the Contract Documents and is to be read in conjunction with all other Contract Documents.

Contractor must verify all dimensions on the project site and report any discrepancies before proceeding with the work. The Contractor shall assume responsibility should the Contractor elect to proceed without reporting any discrepancies.

Drawings are not to be scaled.

All work to be performed must be in compliance with the Ontario Building Code and all other applicable Publications and Authorities having jurisdiction.

1 ISSUED FOR DISCUSSION NO. DESCRIPTION DATE ISSUE RECORD

Gerrard's Design and Drafting Inc.
7 Cloverdale Crescent, Mannheim,
Ontario, N0B 2H0
Phone 519.579.3306 / e-mail jim@gerrards.ca

PROJECT TITLE:

NEW COMMERCIAL/ INDUSTRIAL BUILDING 10045 HIGHWAY 26 COLLINGWOOD, ONTARIO

DRAWING TITLE:

BUILDING 'A' - DESIGN

DRW'N BY:	M. A. CARROLL
CHK'D BY:	J. D. GERRARD
DATE:	MARCH 4, 2024

SCALE: 3/32" = 1'-0"

PROJECT NO. 23GD106

DWG NO. D-3





This drawing is an instrument of service and is the property of Gerrard's Design & Drafting Inc. and cannot be modified and/or reproduced without the permission of Gerrard's Design & Drafting Inc.

© Copyright - Gerrard's Design & Drafting Inc. All Rights Reserved.

This drawing form part of the Contract Documents and is to be read in conjunction with all other Contract Documents.

Contractor must verify all dimensions on the project site and report any discrepancies before proceeding with the work. The Contractor shall assume responsibility should the Contractor elect to proceed without reporting any discrepancies.

Drawings are not to be scaled.

All work to be performed must be in compliance with the Ontario Building Code and all other applicable Publications and Authorities having jurisdiction.

1 ISSUED FOR DISCUSSION NO. DESCRIPTION DATE ISSUE RECORD

Gerrard's Design and Drafting Inc.
7 Cloverdale Crescent, Mannheim,
Ontario, N0B 2H0
Phone 519.579.3306 / e-mail jim@gerrards.ca

PROJECT TITLE:

NEW COMMERCIAL/ INDUSTRIAL BUILDING 10045 HIGHWAY 26 COLLINGWOOD, ONTARIO

DRAWING TITLE:

PROJECT NO.

23GD106

BUILDING 'A' - DESIGN

DRW'N BY:	M. A. CARROLL
CHK'D BY:	J. D. GERRARD
DATE:	MARCH 4, 2024
SCALE:	3/32" = 1'-0"

DWG NO.

D-4



1 NORTH SITE ISOMETRIC



SOUTH SITE ISOMETRIC

D-5

This drawing is an instrument of service and is the property of Gerrard's Design & Drafting Inc. and cannot be modified and/or reproduced without the permission of Gerrard's Design & Drafting Inc.

© Copyright - Gerrard's Design & Drafting Inc. All Rights Reserved.

This drawing form part of the Contract Documents and is to be read in conjunction with all other Contract Documents.

Contractor must verify all dimensions on the project site and report any discrepancies before proceeding with the work. The Contractor shall assume responsibility should the Contractor elect to proceed without reporting any discrepancies.

Drawings are not to be scaled.

All work to be performed must be in compliance with the Ontario Building Code and all other applicable Publications and Authorities having jurisdiction.

1	ISSUED FOR DISCUSSION	-
NO.	DESCRIPTION	DATE
ISS	UE RECORD	

Gerrard's Design and Drafting Inc.
7 Cloverdale Crescent, Mannheim,
Ontario, N0B 2H0
Phone 519.579.3306 / e-mail jim@gerrards.ca

PROJECT TITLE:

NEW COMMERCIAL/INDUSTRIAL BUILDING

10045 HIGHWAY 26
COLLINGWOOD, ONTARIO

DRAWING TI

BUILDING A & B ISOMETRIC

DRW'N BY:	M. A. CARRO	DLL	
CHK'D BY:	J. D. GERRAI	RD	
DATE:	MARCH 4, 2024		
SCALE:			
PROJECT NO. 23GD106		DWG NO.	